

VISUAL SCALE 1:50 @ A3

1 Existing Ground Floor

1 : 50

GENERAL NOTES:

1. DO NOT SCALE FROM THE DRAWINGS
2. ALL DIMENSIONS ARE IN MILLIMETER.
3. VERIFY ALL DIMENSIONS AND CONDITIONS BEFORE BUILDING OR STARTING CONSTRUCTION.
4. NOTIFY THE DESIGNER IMMEDIATELY OF ANY DISCREPANCY OR VARIATION.
5. ALL WORK TO COMPLY WITH CURRENT BUILDING REGULATIONS AND CODES OF PRACTICE.



NISARG@HOTMAIL.COM

+44 - 7951491310


PROJECT
70 Bempton Drive Ruislip HA4 9DE

SHEET
Existing Ground Floor Plan


CLIENT		Mrs N Nagpal	
Date	Project number	Scale (@ A3)	
Issue Date	Project Number		
Drawn by	DRWAING NUMBER	REV	
Author	A101		
Checked by			
Checker			




1 Existing Front_Elevation
1 : 100

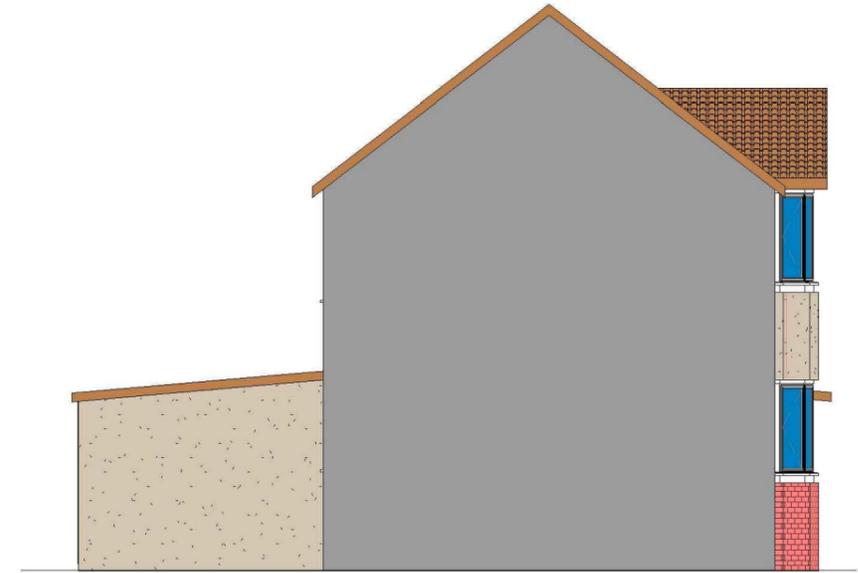

2 Existing Side 01_Elevation
1 : 100

 

VISUAL SCALE 1:100 @ A3

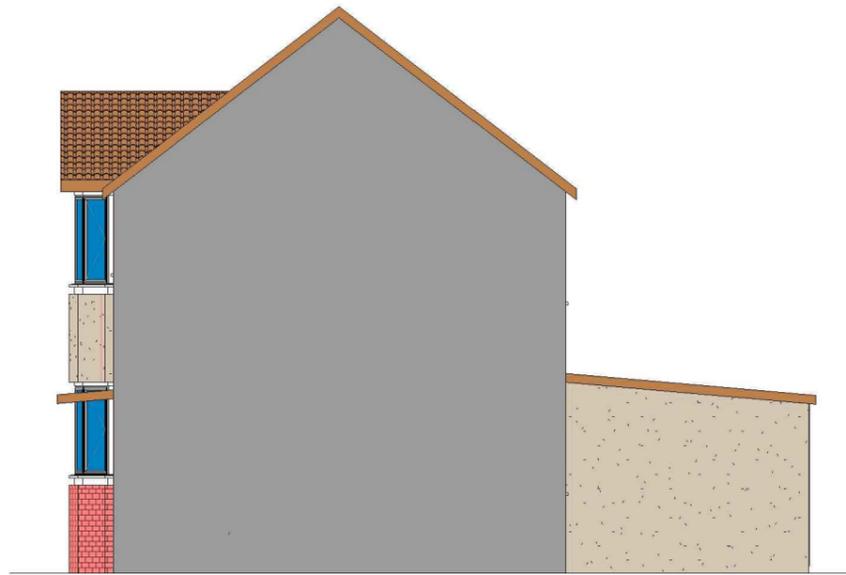

4 Existing Side 02_Elevation
1 : 100



3 Existing Rear_Elevation
1 : 100

GENERAL NOTES:

1. DO NOT SCALE FROM THE DRAWINGS
2. ALL DIMENSIONS ARE IN MILLIMETER.
3. VERIFY ALL DIMENSIONS AND CONDITIONS BEFORE BUILDING OR STARTING CONSTRUCTION.
4. NOTIFY THE DESIGNER IMMEDIATELY OF ANY DISCREPANCY OR VARIATION.
5. ALL WORK TO COMPLY WITH CURRENT BUILDING REGULATIONS AND CODES OF PRACTICE.



Art @ Rooshika

NISARG@HOTMAIL.COM

+44 - 7951491310

PROJECT
70 Bempton Drive Ruislip HA4 9DE

SHEET
Existing Elevations

CLIENT		Mrs N Nagpal	
Date	Project number	Scale (@ A3)	
Issue Date	Project Number		
Drawn by	DRWAING NUMBER	REV	
Author	A102		
Checked by			
Checker			

FD 30 Fire check doors 30 min fire resistance with smoke seal and self closing

HD Heat Detector comply with BS 5466 2:2016

Smoke alarm/detector to comply with BS EN14604

EL Emergency lights To be Installed in Accordance with BS5266: 2016



VISUAL SCALE 1:50 @ A3

- Assembly Point
- Foam 6 litre foam spray
- Call Point

Fire Alarm System comply with BS 5839:Part 1:2017


FIRE EXIT Fire Exit Sign Comply with BS 5499

CM Carbon Monoxide Detector

Extract Vent

The existing partitions forming the protected staircase must provide half-hour fire resistance. They must be lined with 12.5mm plasterboard and skim

The doors to Bedrooms and any habitable rooms and the final exit door must not be fitted with a key on the inside. Thumb turns are acceptable

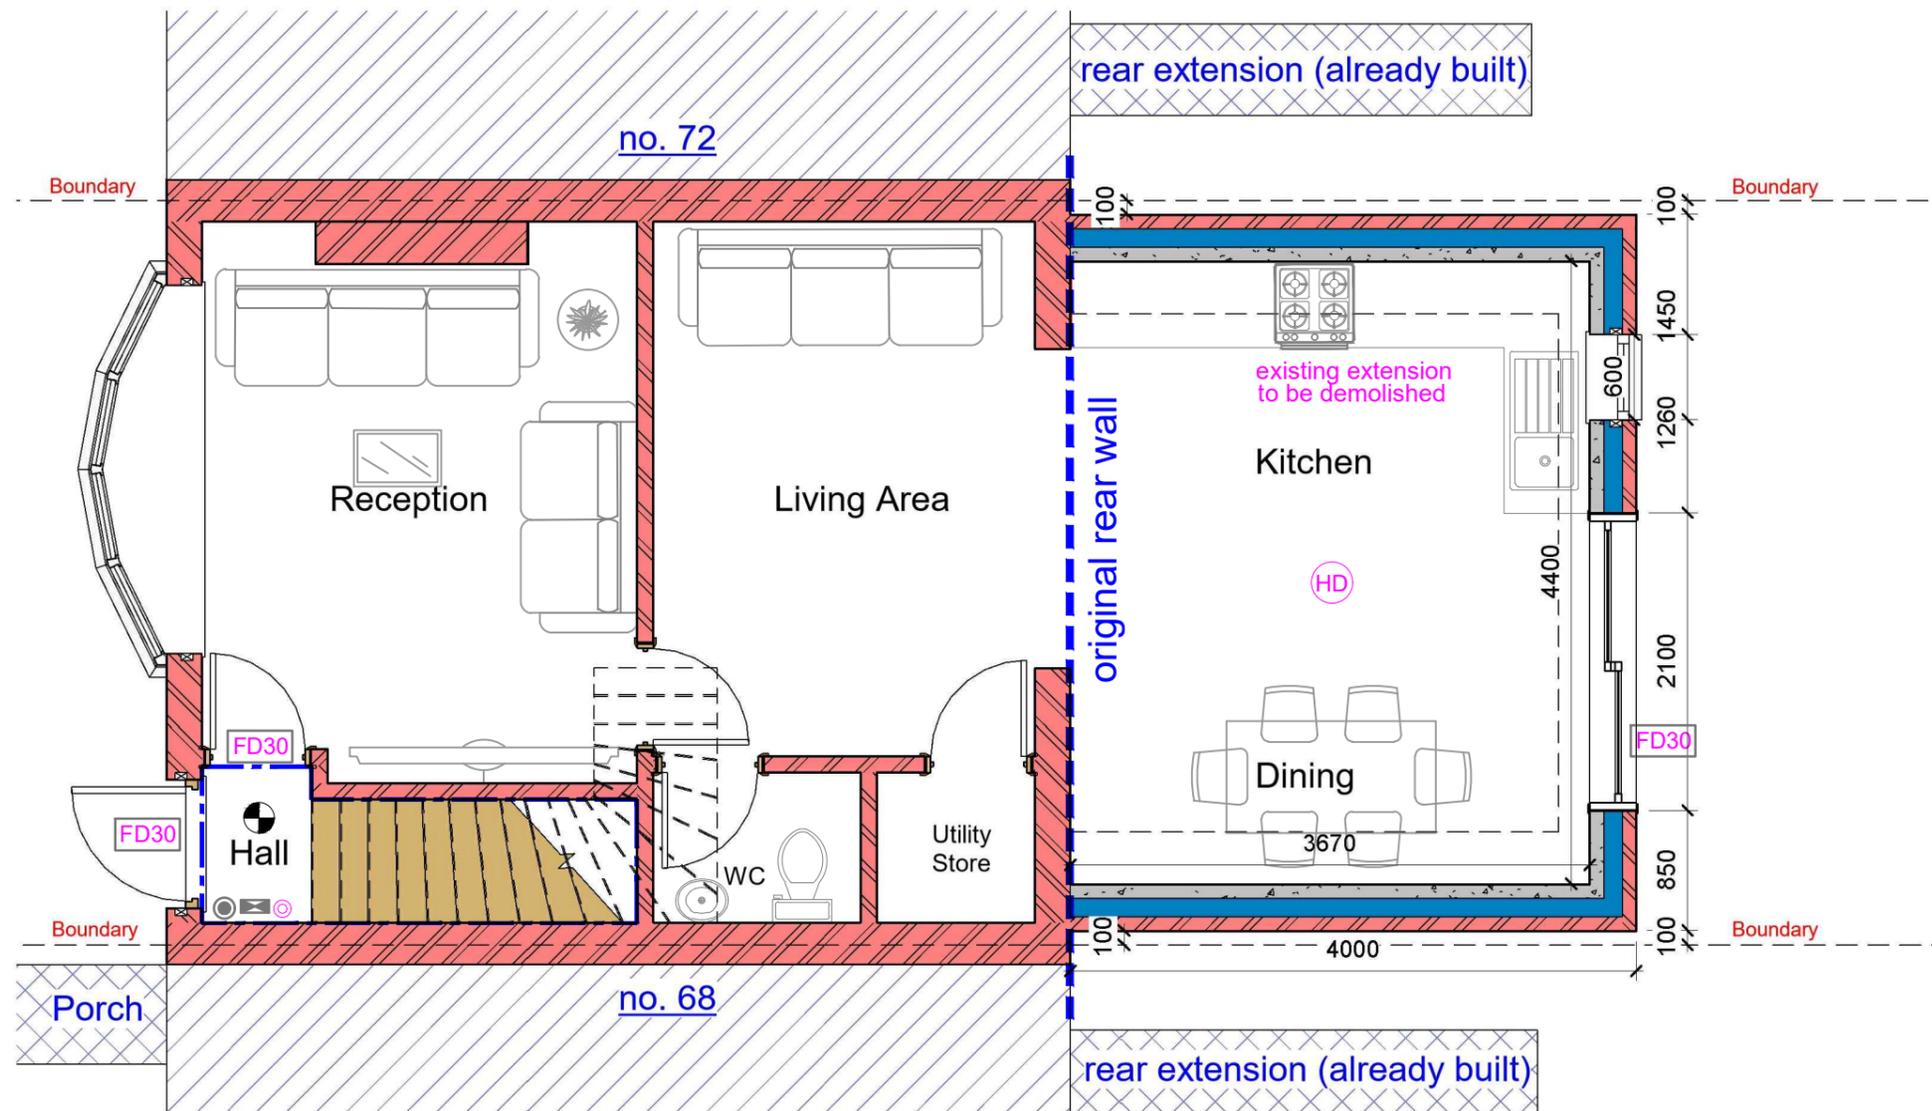

1 Proposed Ground Floor

1 : 50

GENERAL NOTES:

1. DO NOT SCALE FROM THE DRAWINGS
2. ALL DIMENSIONS ARE IN MILLIMETER.
3. VERIFY ALL DIMENSIONS AND CONDITIONS BEFORE BUILDING OR STARTING CONSTRUCTION.
4. NOTIFY THE DESIGNER IMMEDIATELY OF ANY DISCREPANCY OR VARIATION.
5. ALL WORK TO COMPLY WITH CURRENT BUILDING REGULATIONS AND CODES OF PRACTICE.



Art @ Rooshika

NISARG@HOTMAIL.COM

+44 - 7951491310

PROJECT
70 Bempton Drive Ruislip HA4 9DE

SHEET
Proposed Ground Floor Plan

CLIENT
Mrs N Nagpal

Date	Project number	Scale (@ A3)
Issue Date	Project Number	
Drawn by	DRWAING NUMBER	REV
Author	A103	
Checked by		
Checker		





ALL PROPOSED MATERIALS/FINISHED TO MATCH WITH EXISTING.



1 Proposed Side 01_Elevation
1 : 100

2 Proposed Front_Elevation
1 : 100

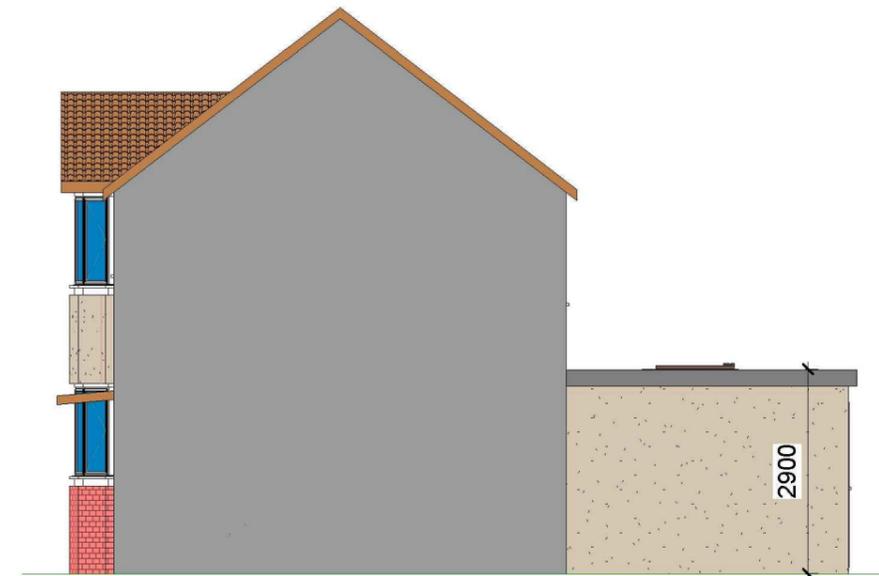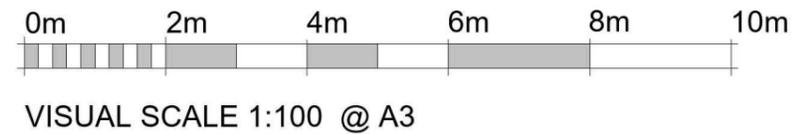

3 Proposed Rear_Elevation
1 : 100

4 Proposed Side 02_Elevation
1 : 100

GENERAL NOTES:

1. DO NOT SCALE FROM THE DRAWINGS
2. ALL DIMENSIONS ARE IN MILLIMETER.
3. VERIFY ALL DIMENSIONS AND CONDITIONS BEFORE BUILDING OR STARTING CONSTRUCTION.
4. NOTIFY THE DESIGNER IMMEDIATELY OF ANY DISCREPANCY OR VARIATION.
5. ALL WORK TO COMPLY WITH CURRENT BUILDING REGULATIONS AND CODES OF PRACTICE.



Art @ Rooshika



NISARG@HOTMAIL.COM

+44 - 7951491310


PROJECT
70 Bempton Drive Ruislip HA4 9DE

SHEET
Proposed Elevations

CLIENT Mrs N Nagpal		
Date	Project number	Scale (@ A3)
Issue Date	Project Number	
Drawn by	DRWAING NUMBER	REV
Author	A104	
Checked by		
Checker		

 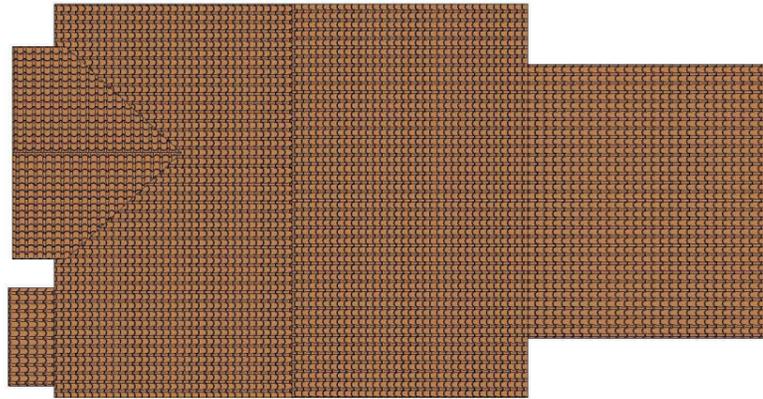


VISUAL SCALE 1:100 @ A3

 

VISUAL SCALE 1:50 @ A3

1 Existing Roof
1 : 100

2 Proposed Roof
1 : 50

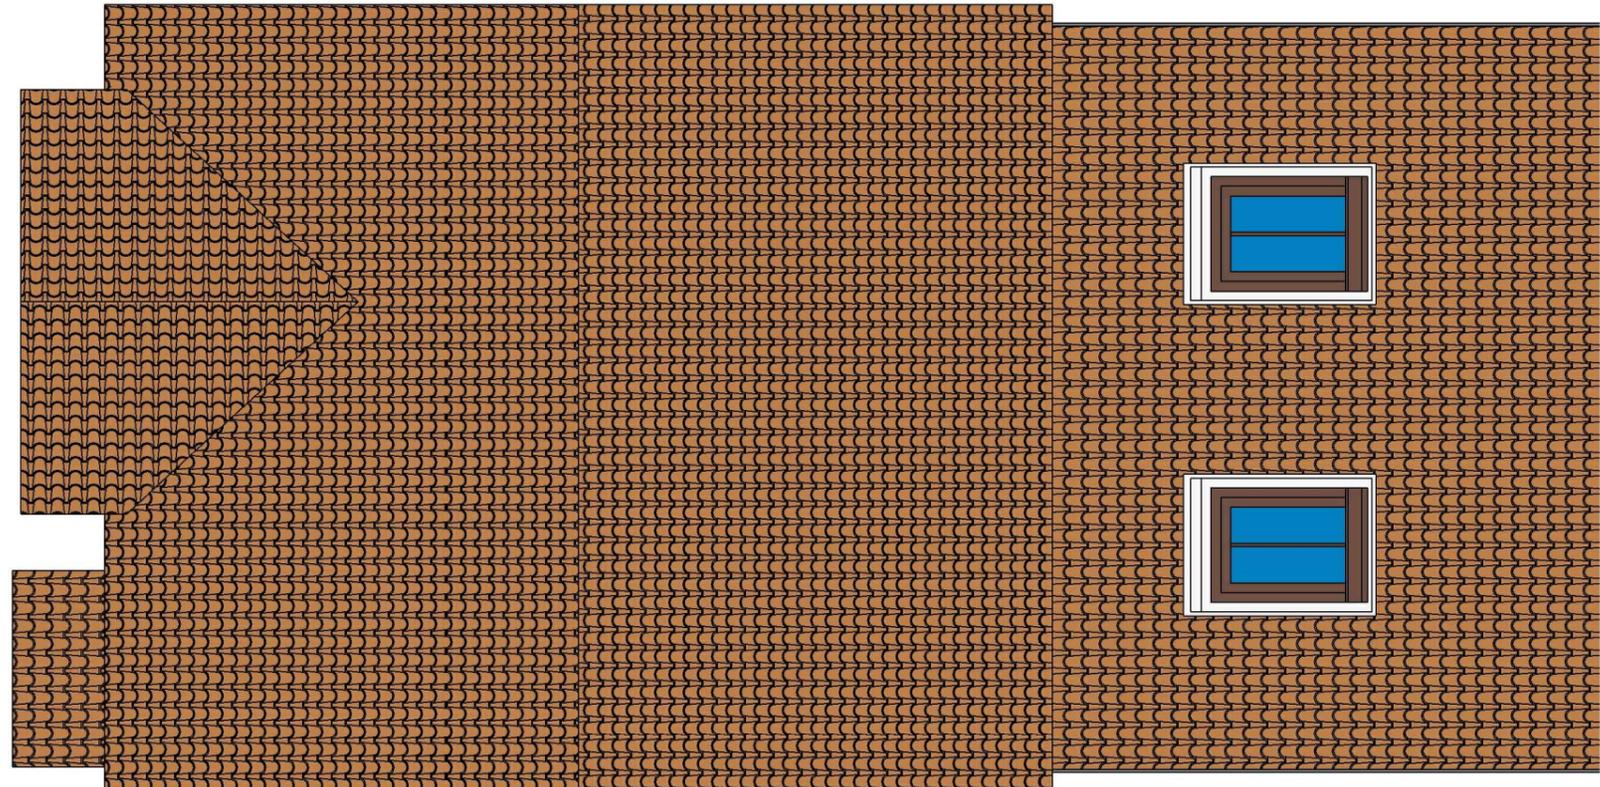

GENERAL NOTES:

1. DO NOT SCALE FROM THE DRAWINGS
2. ALL DIMENSIONS ARE IN MILLIMETER.
3. VERIFY ALL DIMENSIONS AND CONDITIONS BEFORE BUILDING OR STARTING CONSTRUCTION.
4. NOTIFY THE DESIGNER IMMEDIATELY OF ANY DISCREPANCY OR VARIATION.
5. ALL WORK TO COMPLY WITH CURRENT BUILDING REGULATIONS AND CODES OF PRACTICE.



Art @ Rooshika

NISARG@HOTMAIL.COM

+44 - 7951491310

PROJECT

70 Bempton Drive Ruislip HA4 9DE


SHEET

Existing & Proposed Roof Plan

CLIENT

Mrs N Nagpal

Date	Project number	Scale (@ A3)
Issue Date	Project Number	
Drawn by	DRWAING NUMBER	REV
Author	A105	
Checked by		
Checker		

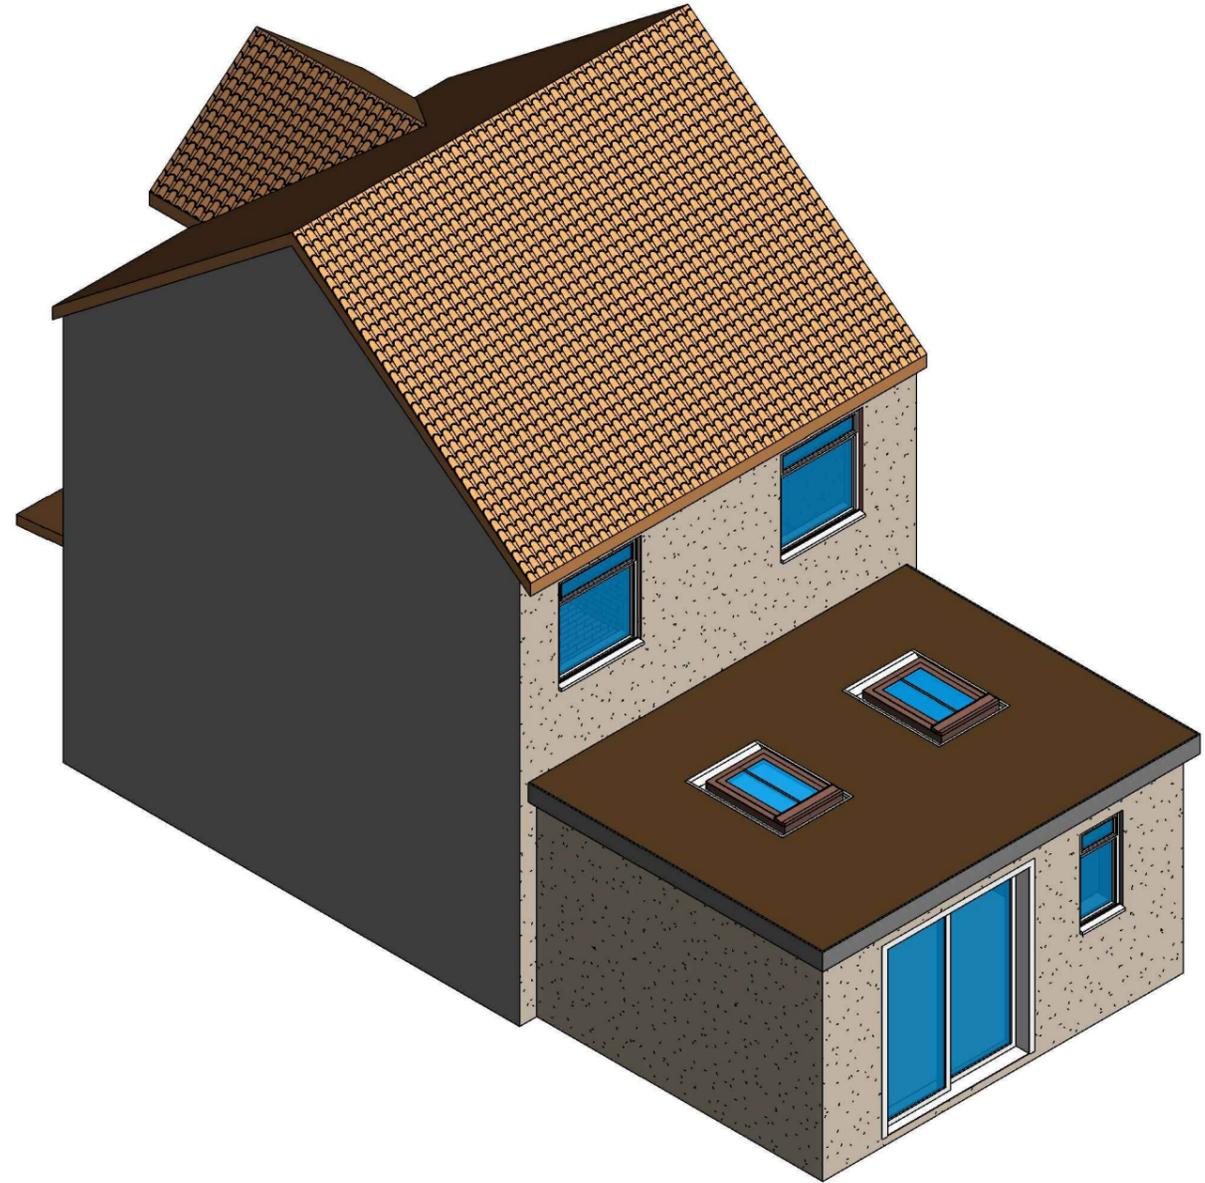

1

3D View 01 Existing

2

3D View 01 Proposed

GENERAL NOTES:

1. DO NOT SCALE FROM THE DRAWINGS
2. ALL DIMENSIONS ARE IN MILLIMETER.
3. VERIFY ALL DIMENSIONS AND CONDITIONS BEFORE BUILDING OR STARTING CONSTRUCTION.
4. NOTIFY THE DESIGNER IMMEDIATELY OF ANY DISCREPANCY OR VARIATION.
5. ALL WORK TO COMPLY WITH CURRENT BUILDING REGULATIONS AND CODES OF PRACTICE.



Art @ Rooshika

NISARG@HOTMAIL.COM

+44 - 7951491310

PROJECT

70 Bempton Drive Ruislip HA4 9DE

SHEET

3D View

CLIENT

Mrs N Nagpal

Date

Issue Date

Drawn by

Author

Checked by

Checker

Project number

Project Number

DRWAING NUMBER

A106

Scale (@ A3)

REV