
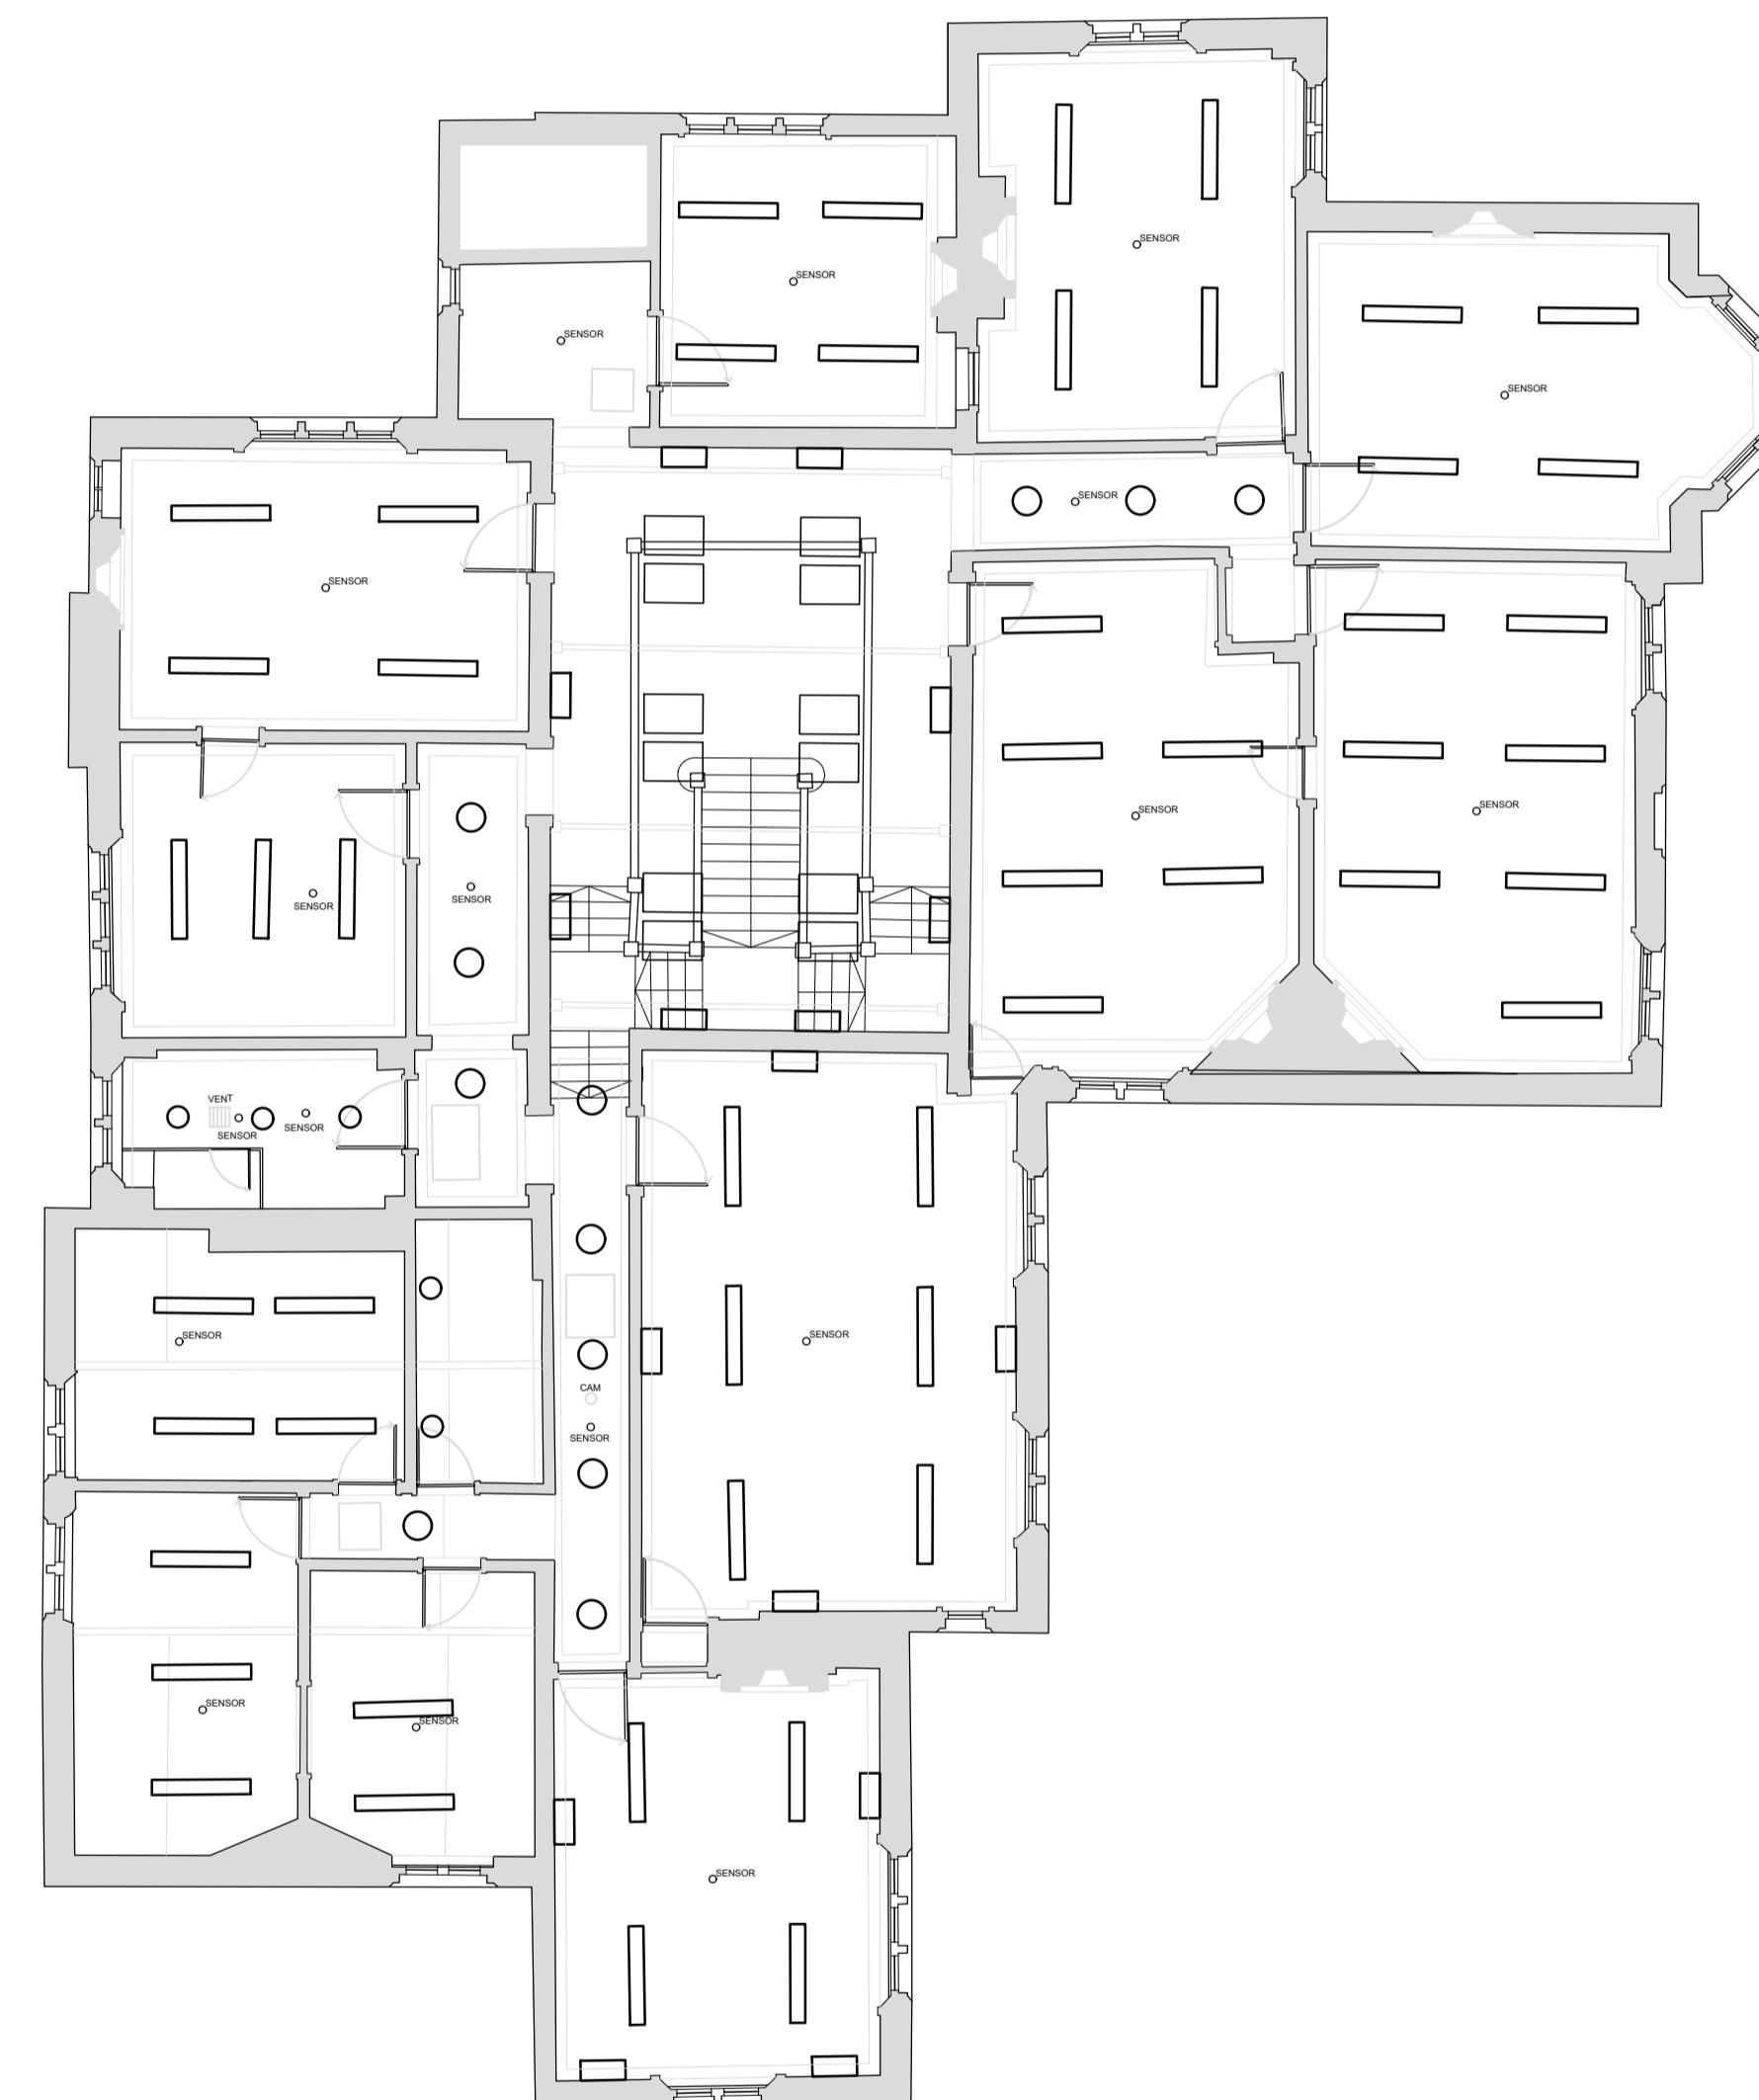


HRUC - Barra Hall SEND College  
 Existing Reflected Ceiling Plans  
 1:100@A1

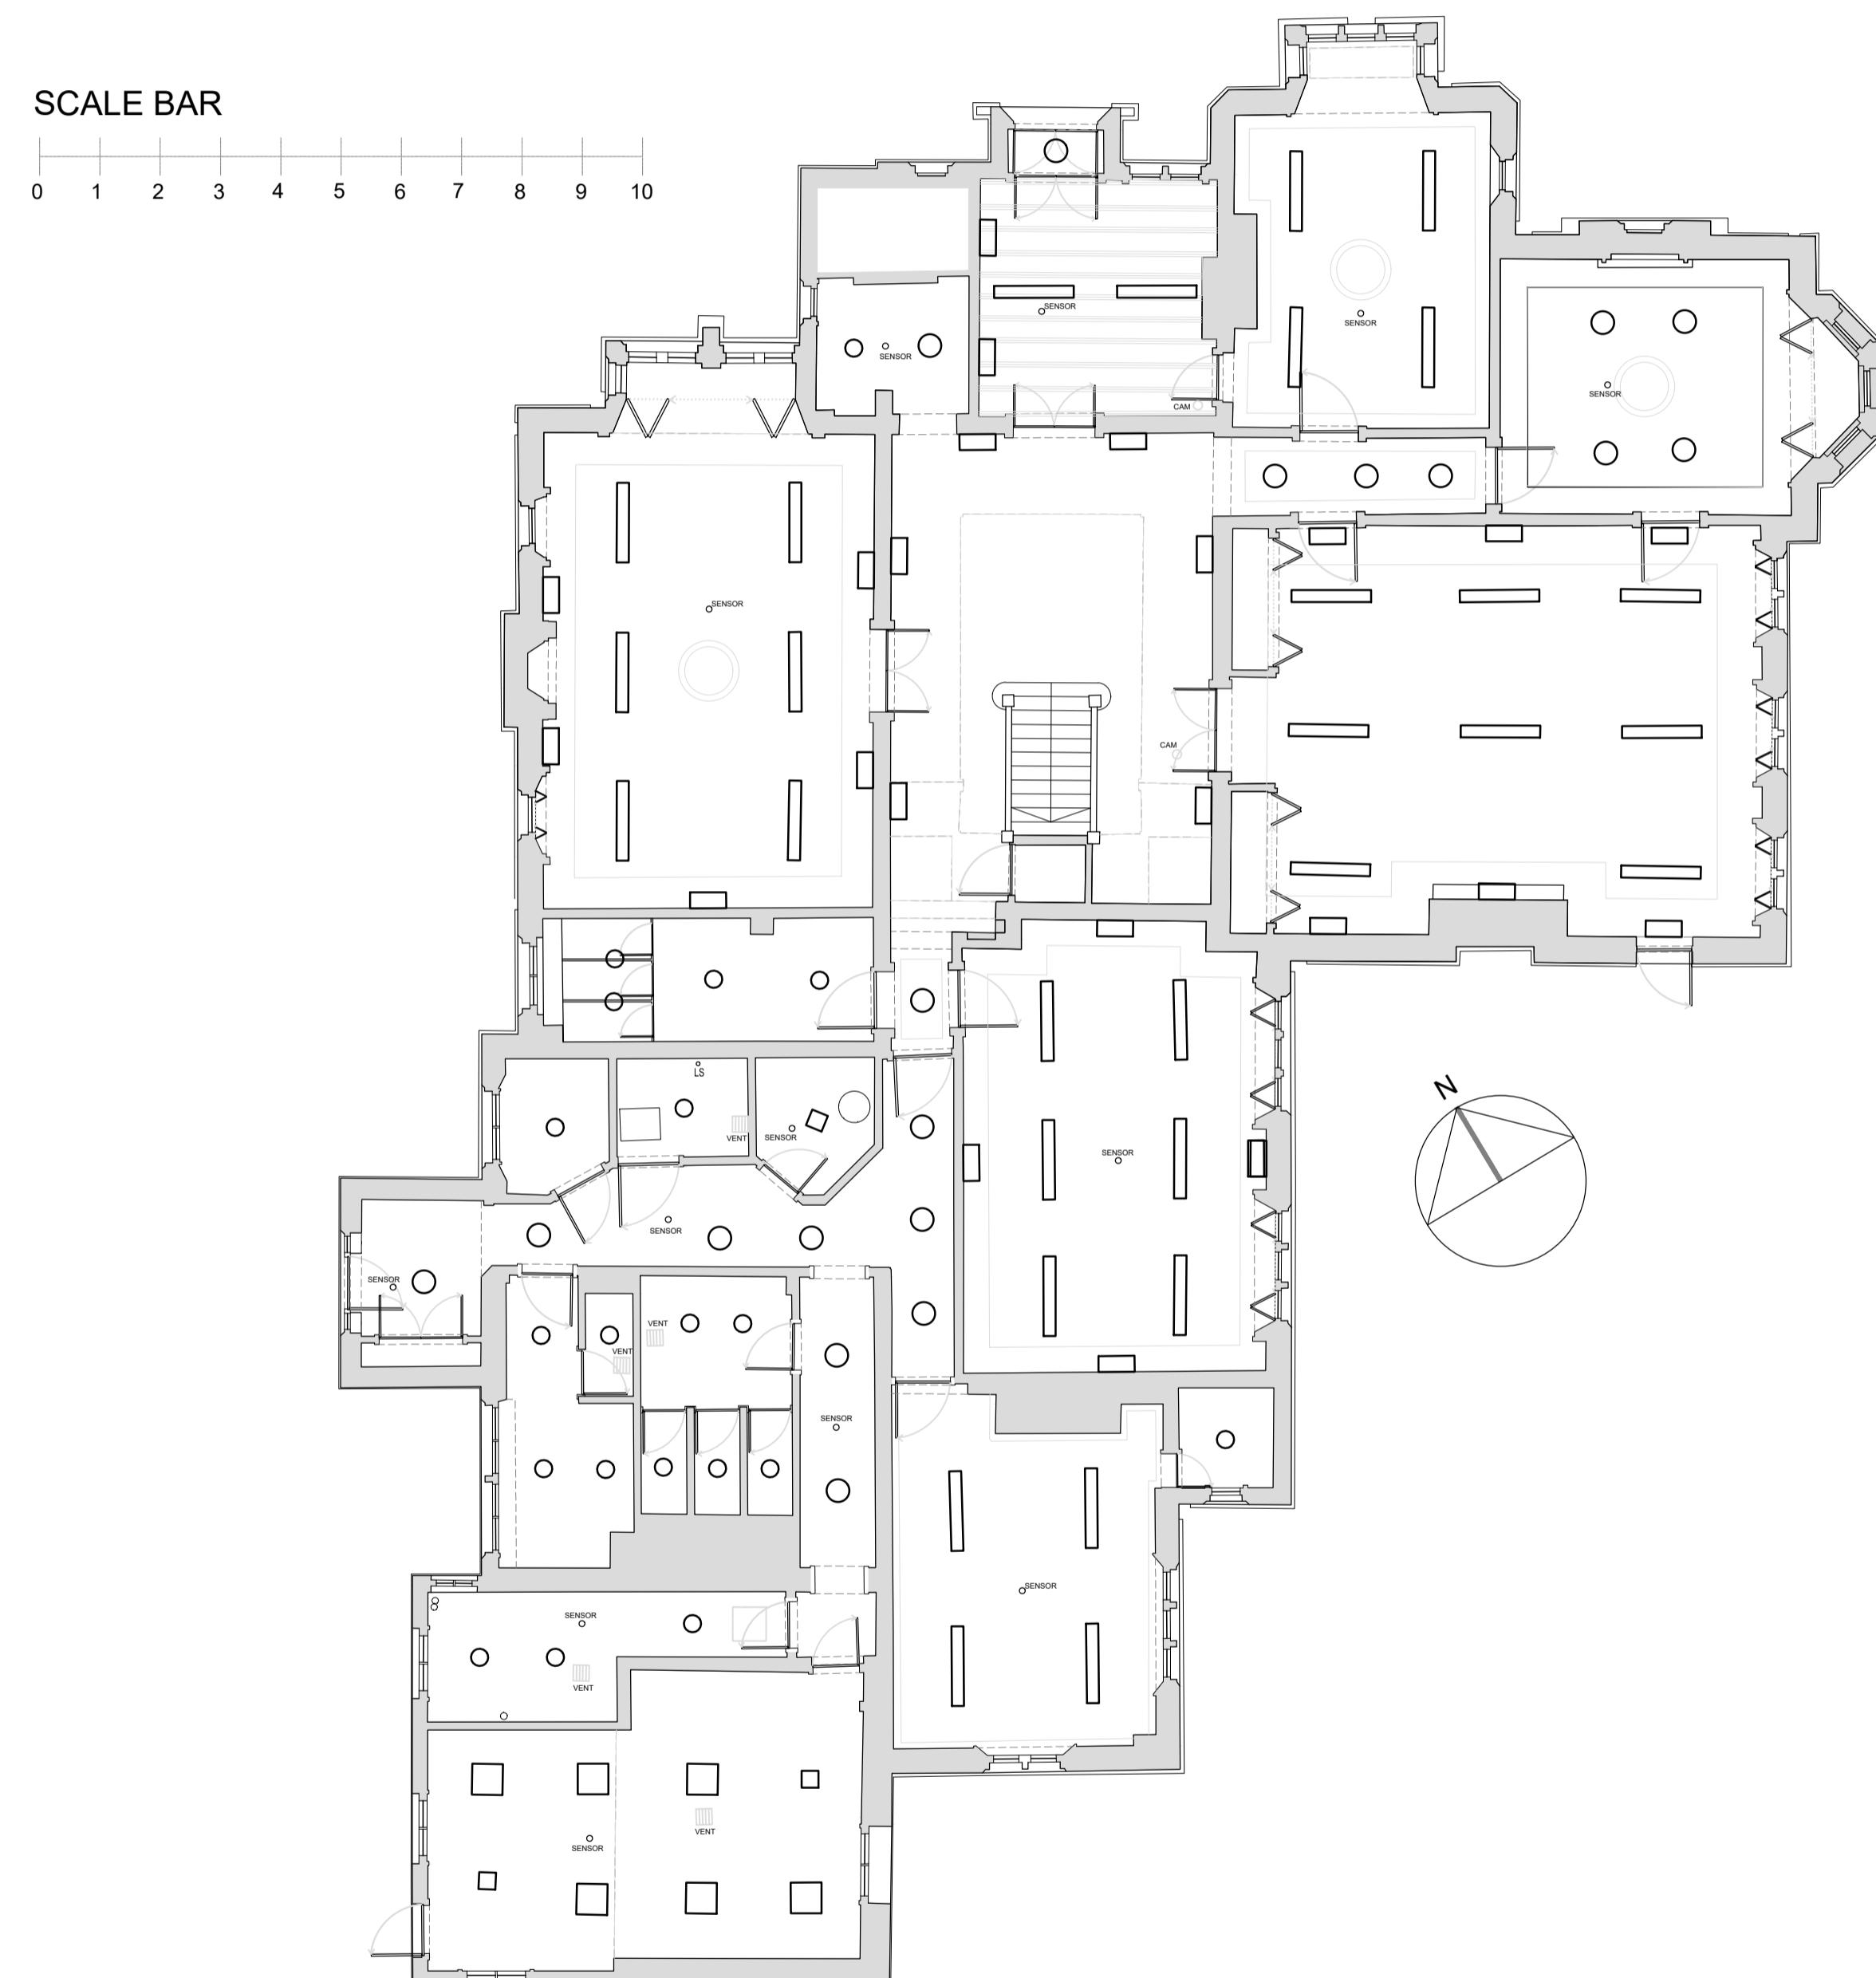

- EXISTING SUSPENDED LIGHT FITTING
- EXISTING WALL MOUNTED UPLIGHTER
- EXISTING DOWNLIGHT
- EXISTING DOWNLIGHT

Project Number TWC 183 | SCALE (@ A1) AS NOTED | DATE 28-Jan-25

CLIENT

HRUC BARRA HALL

PROJECT

BARRA HALL

ADDRESS

WOOD END, HAYES

DRAWING NAME

EXISTING RC PLANS

DRAWING NUMBER RC-001 | REV AS NOTED

DRAWN BY CLC | CHECKED BY ----

The Workspace Consultants LLP  
 1 Avenue Business Park  
 Brockley Road  
 Elsworth, Cambridgeshire  
 CB23 4EY  
 Tel: +44(0)1223 656111



WORKSPACE