



GROUND FLOOR PLAN
scale; 1:50@A1

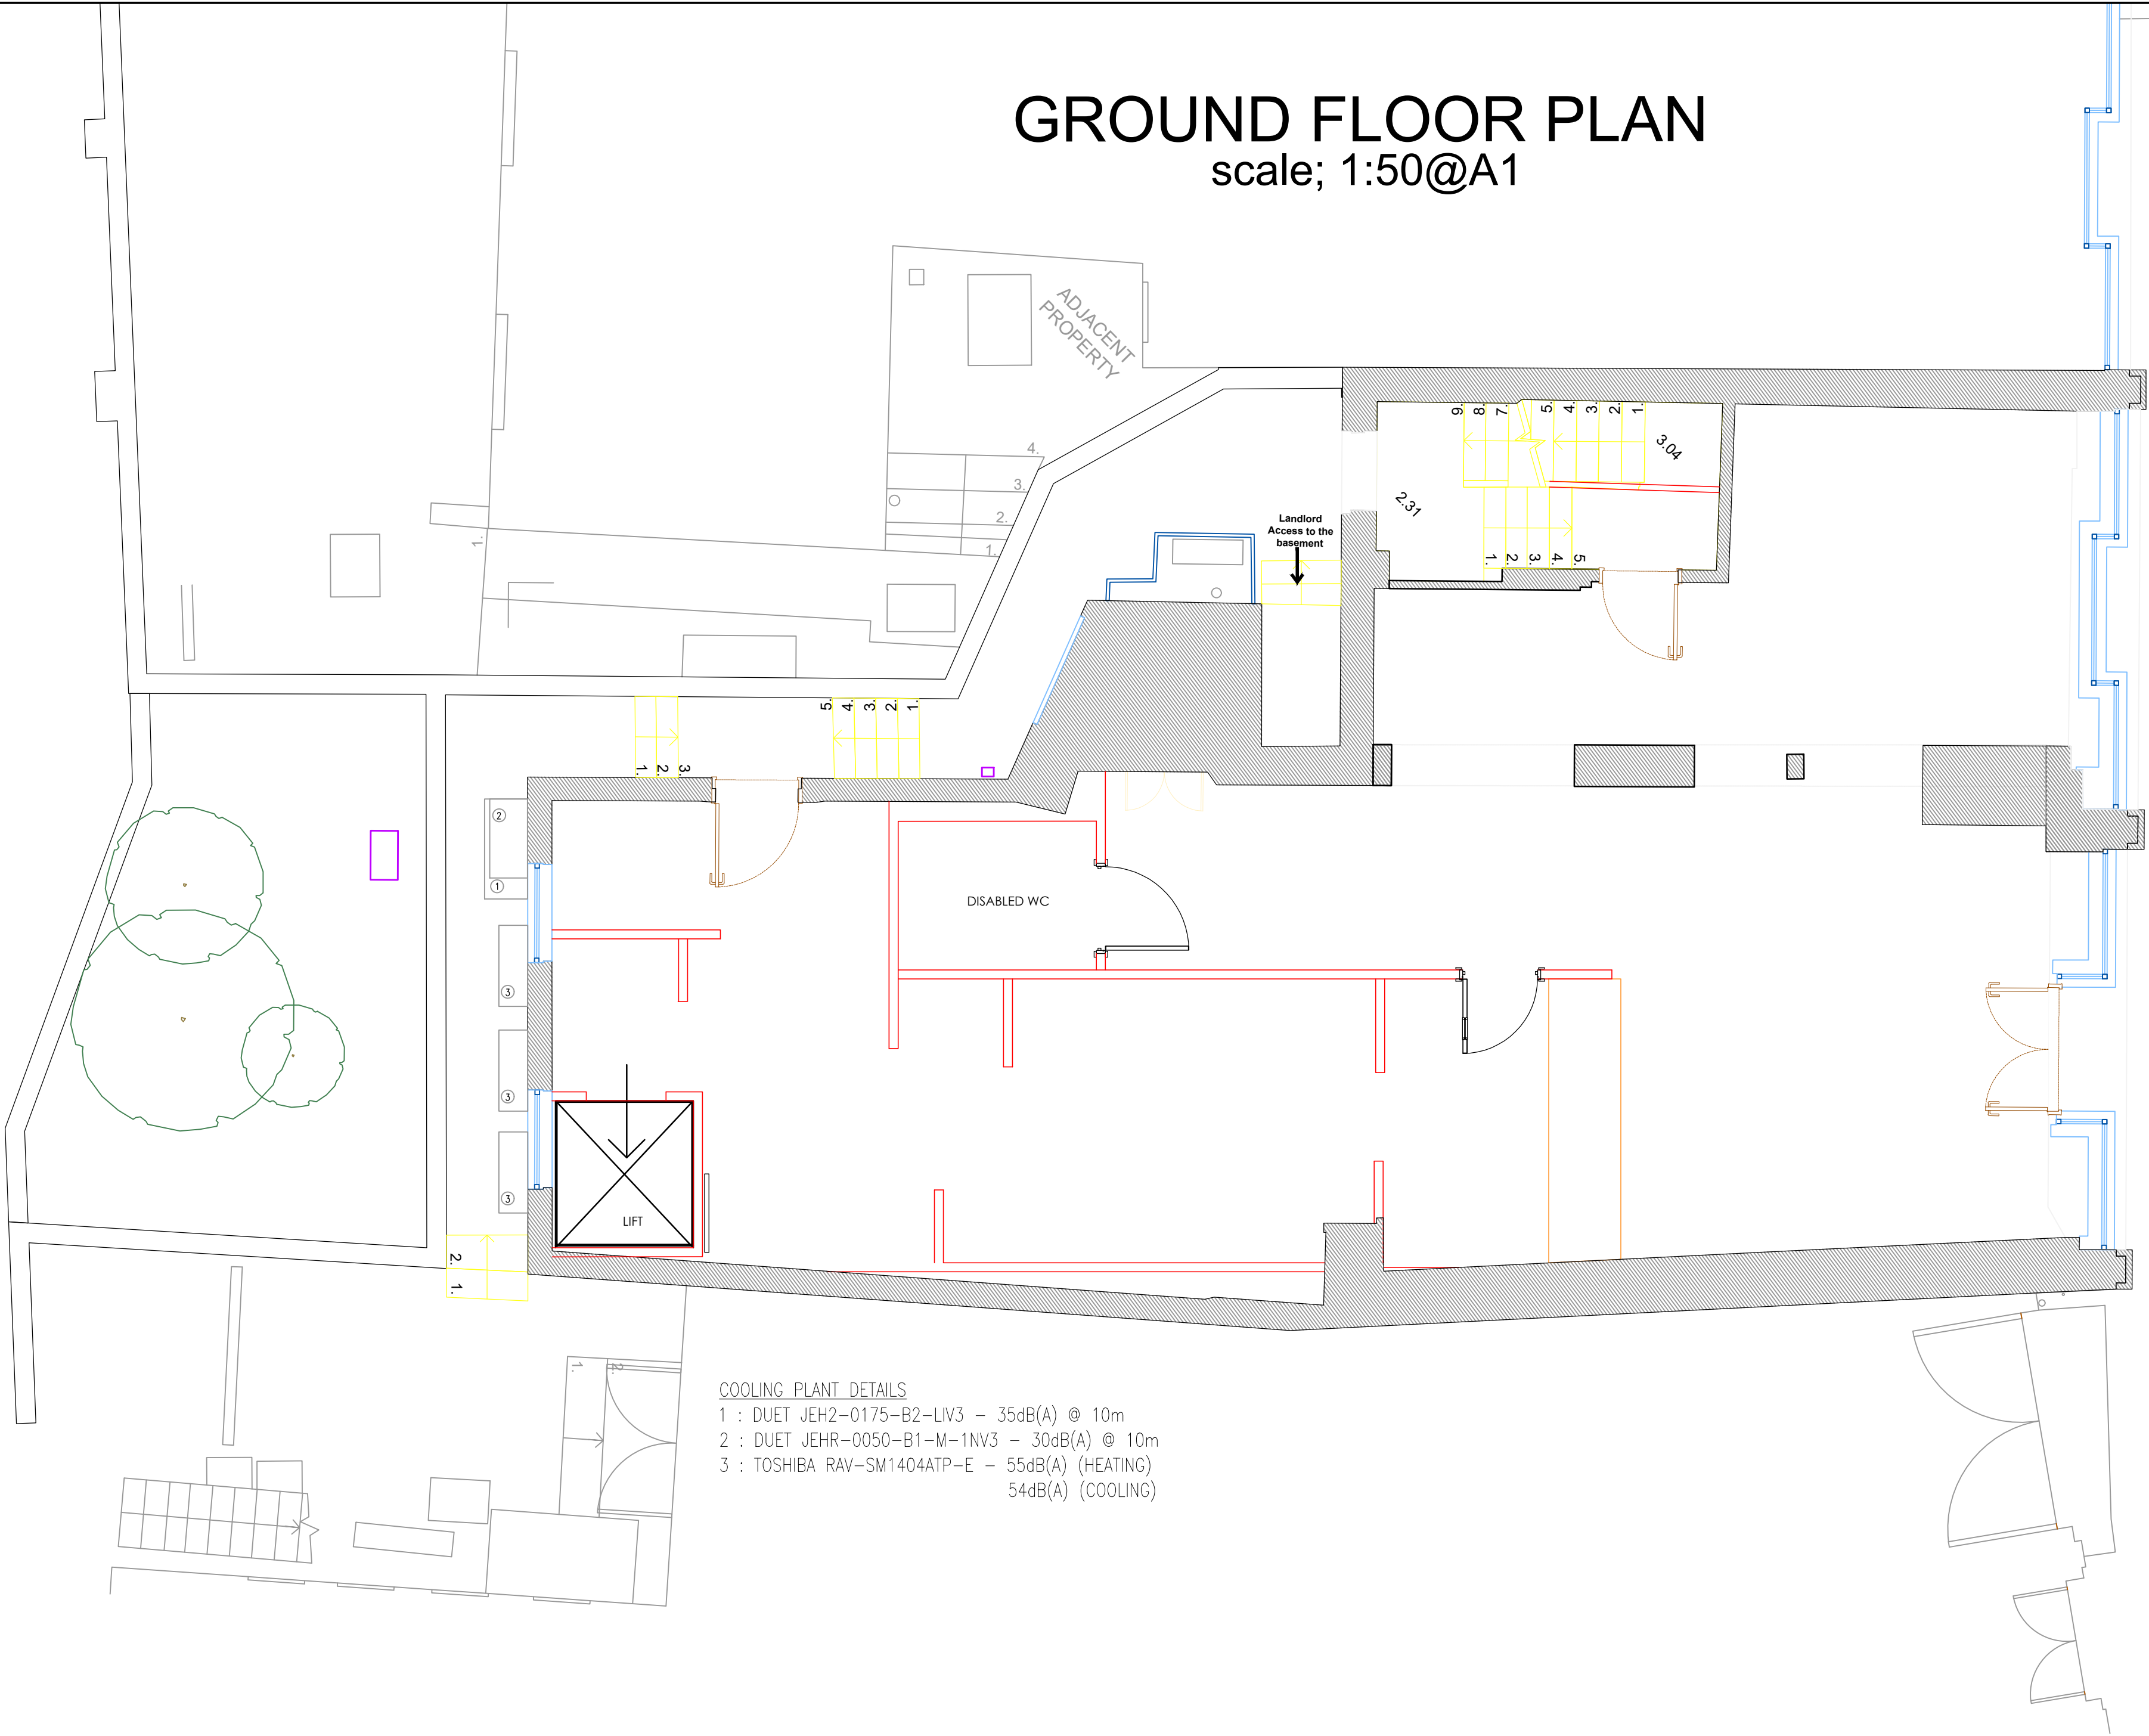

COOLING PLANT DETAILS
1 : DUET JEHR-0050-B1-M-1NV3 - 30dB(A) @ 10m
2 : DUET JEHR-0050-B1-M-1NV3 - 30dB(A) @ 10m
3 : TOSHIBA RAV-SM1404ATP-E - 55dB(A) (HEATING)
54dB(A) (COOLING)

BASEMENT FLOOR PLAN
scale; 1:50 @ A1

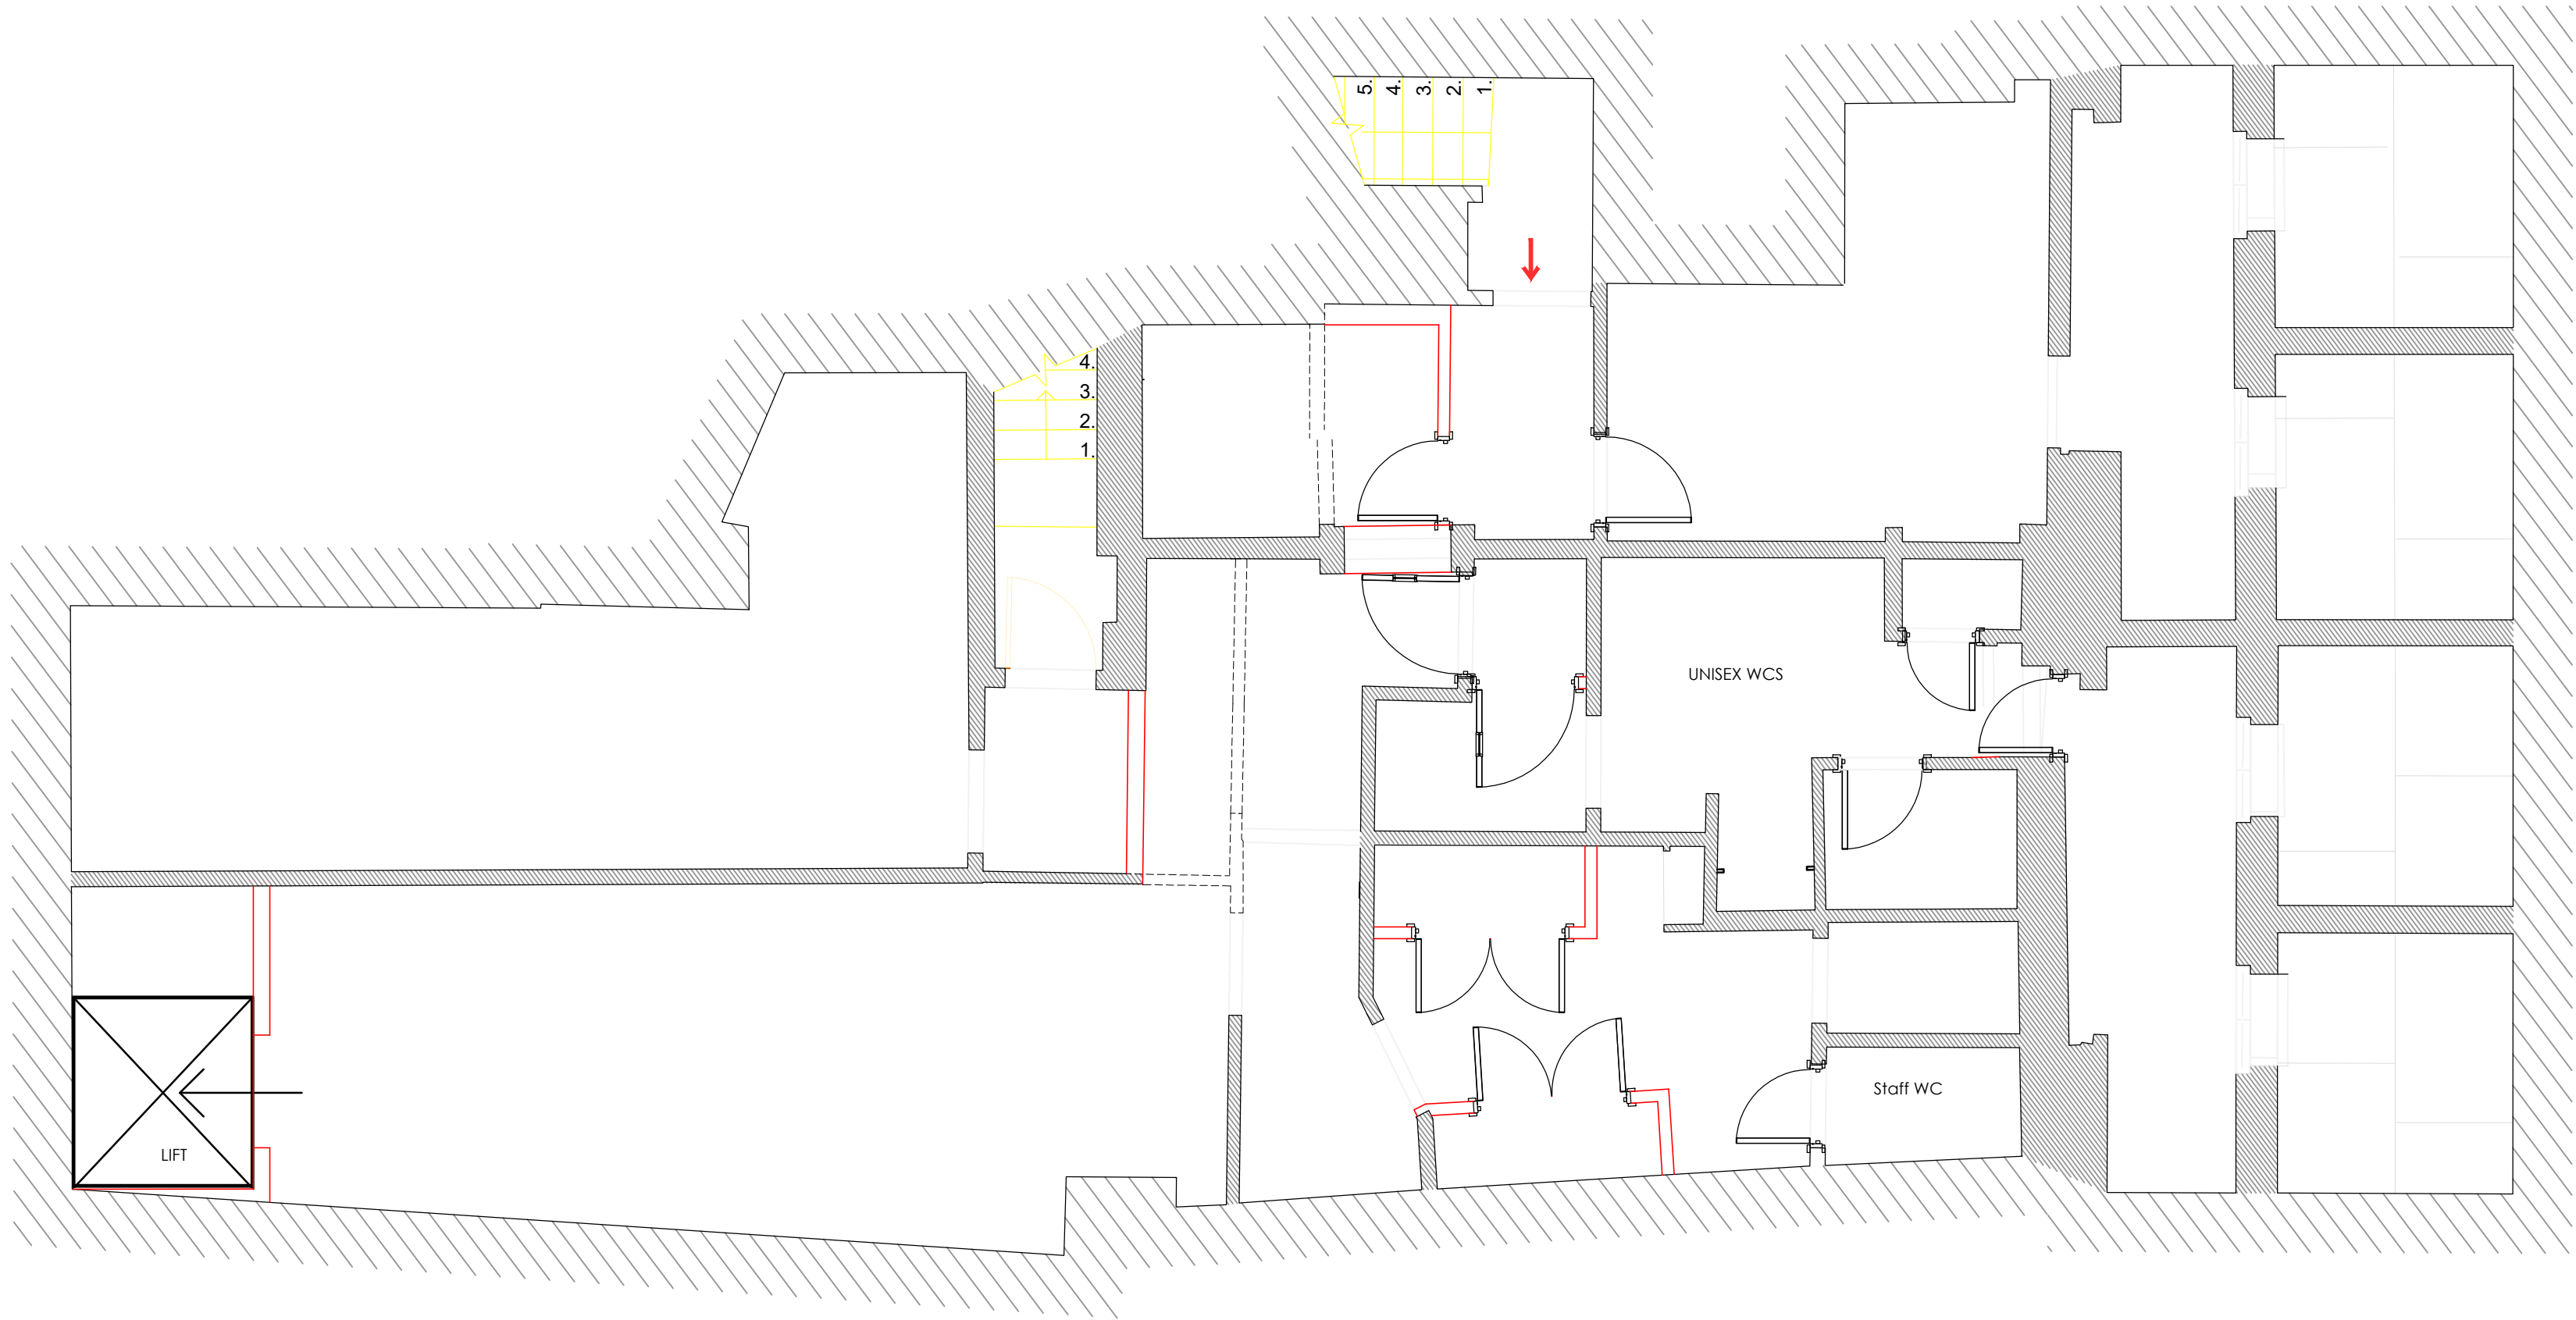

SCALE 1:50 only 0 1 2 3 4 5 10

HONE

EDWARDS

ASSOCIATES

Design Studio

Milars Three

Southmill Road

Bishop's Stortford

Herts. CM23 3DH

email: enquiries@honeedwards.co.uk

Tel: 01279 758545

Fax: 01279 757730

ALL DIMENSIONS TO BE CHECKED ON SITE

DO NOT SCALE FROM THIS DRAWING EXCEPT FOR THE PURPOSES OF LOCAL AUTHORITY PLANNING

CLIENT:

NRB

PROJECT ADDRESS:

TACO BELL

211-213 High Street

Uxbridge

DRAWING TITLE:

PROPOSED PLANS

PLANNING

DRAWN BY:

IE

CHECKED BY:

DATE:

JULY 2021

SCALE:

1:50@A1

STATUS:

PLANNING

DRAWING NO.

3287/PL100

REVISION:

B

REV	DATE	DESCRIPTION
A	20.08.21	Plan updated to suit latest info IE
B	24.08.21	External plant indicated at rear IE
