 


Haydon School


New AGP



CONSULTANTS
Surfacing Standards Ltd
Office 2, Longspan Works,
Aston Road, Gillingham, LE15 9NY
01538 402512


1. DO NOT SCALE FROM DRAWING UNLESS FOR PLANNING PURPOSES ONLY. ALL DIMENSIONS TO BE CHECKED ON SITE PRIOR TO COMMENCEMENT OF WORKS.
2. THIS DRAWING IS COPYRIGHT TO SURFACING STANDARDS LTD.
3. ALL PERSONNEL SHOULD BE AWARE OF THE HEALTH AND SAFETY PLAN WHICH IS RETAINED IN THE SITE MANAGERS OFFICE.

- 80mm Ø Lateral Drain
- 150mm Ø Carrier Drain
- Existing Drainage System

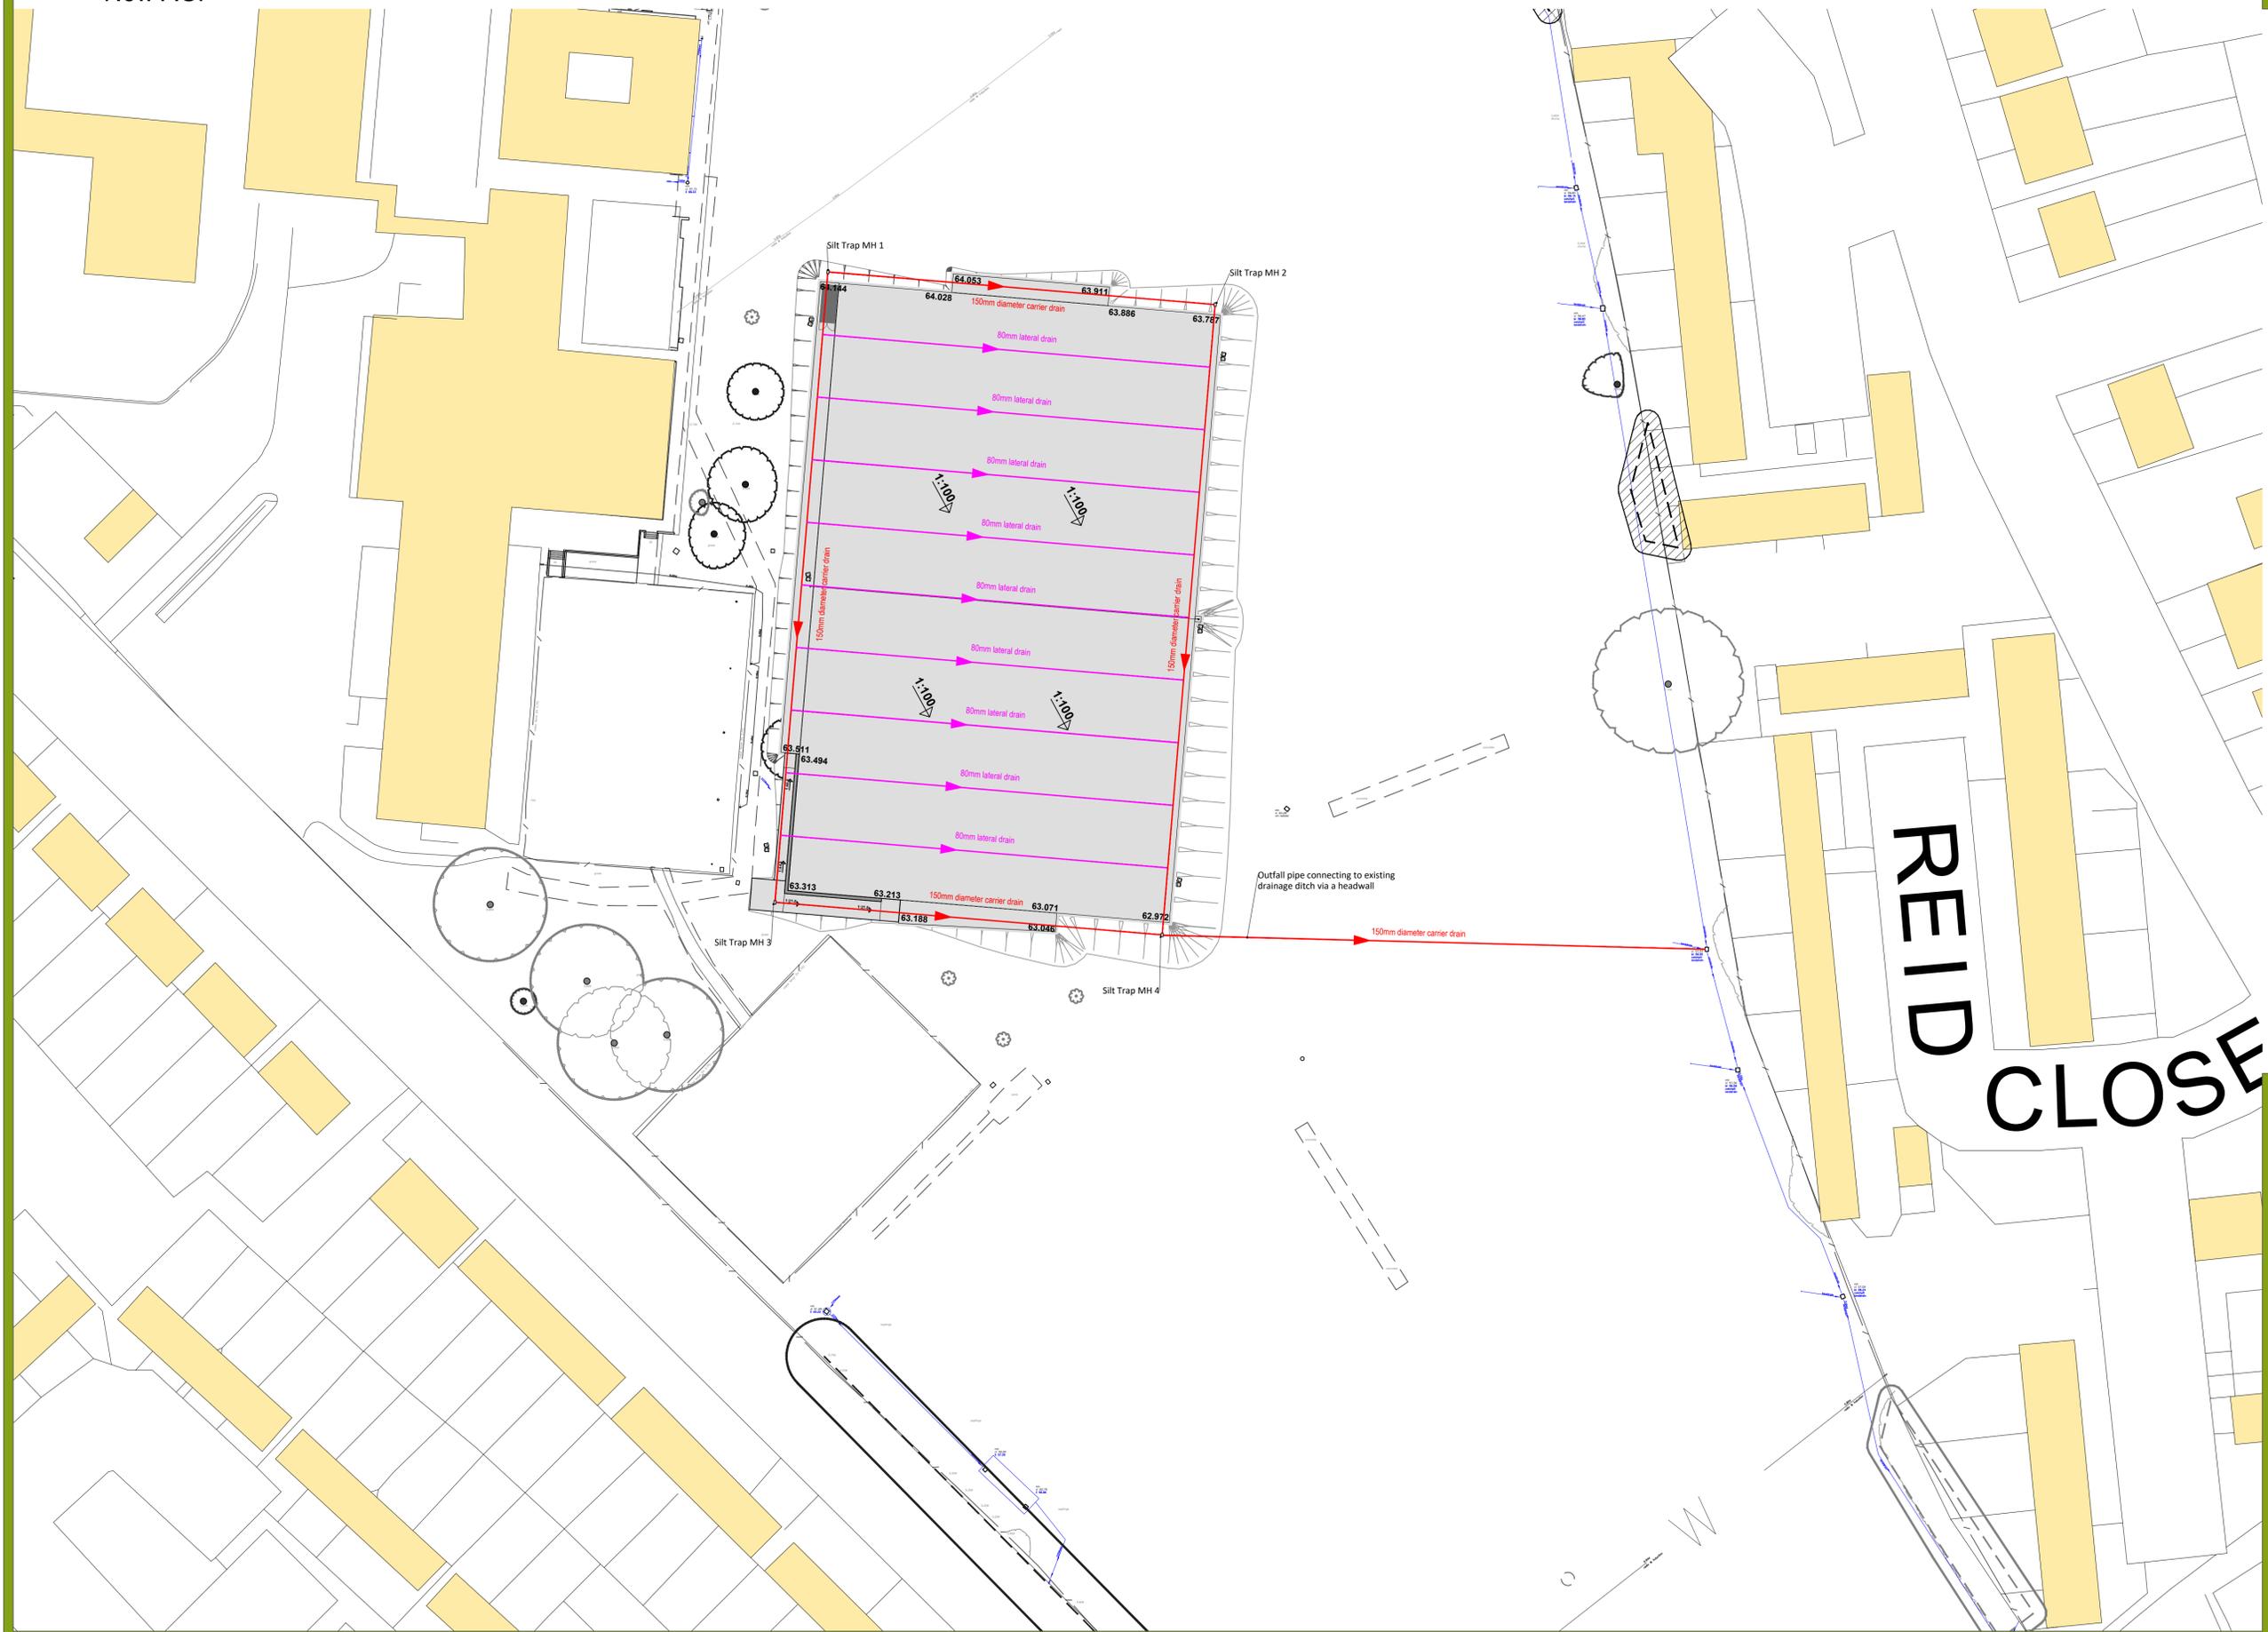

00	PLANNING ISSUE	ME	02/12/25
REV	DESCRIPTION	REV	CK DATE

SSL
Surfacing Standards Limited
SPORTS PITCH CONSULTANTS

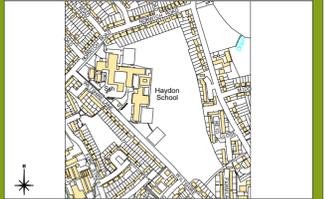

AUTHOR ME	
TITLE Haydon School New AGP Proposed AGP Drainage Layout	
PROJECT G-214594	SCALE 1:500
DRAWING No 07	REVISION 00