


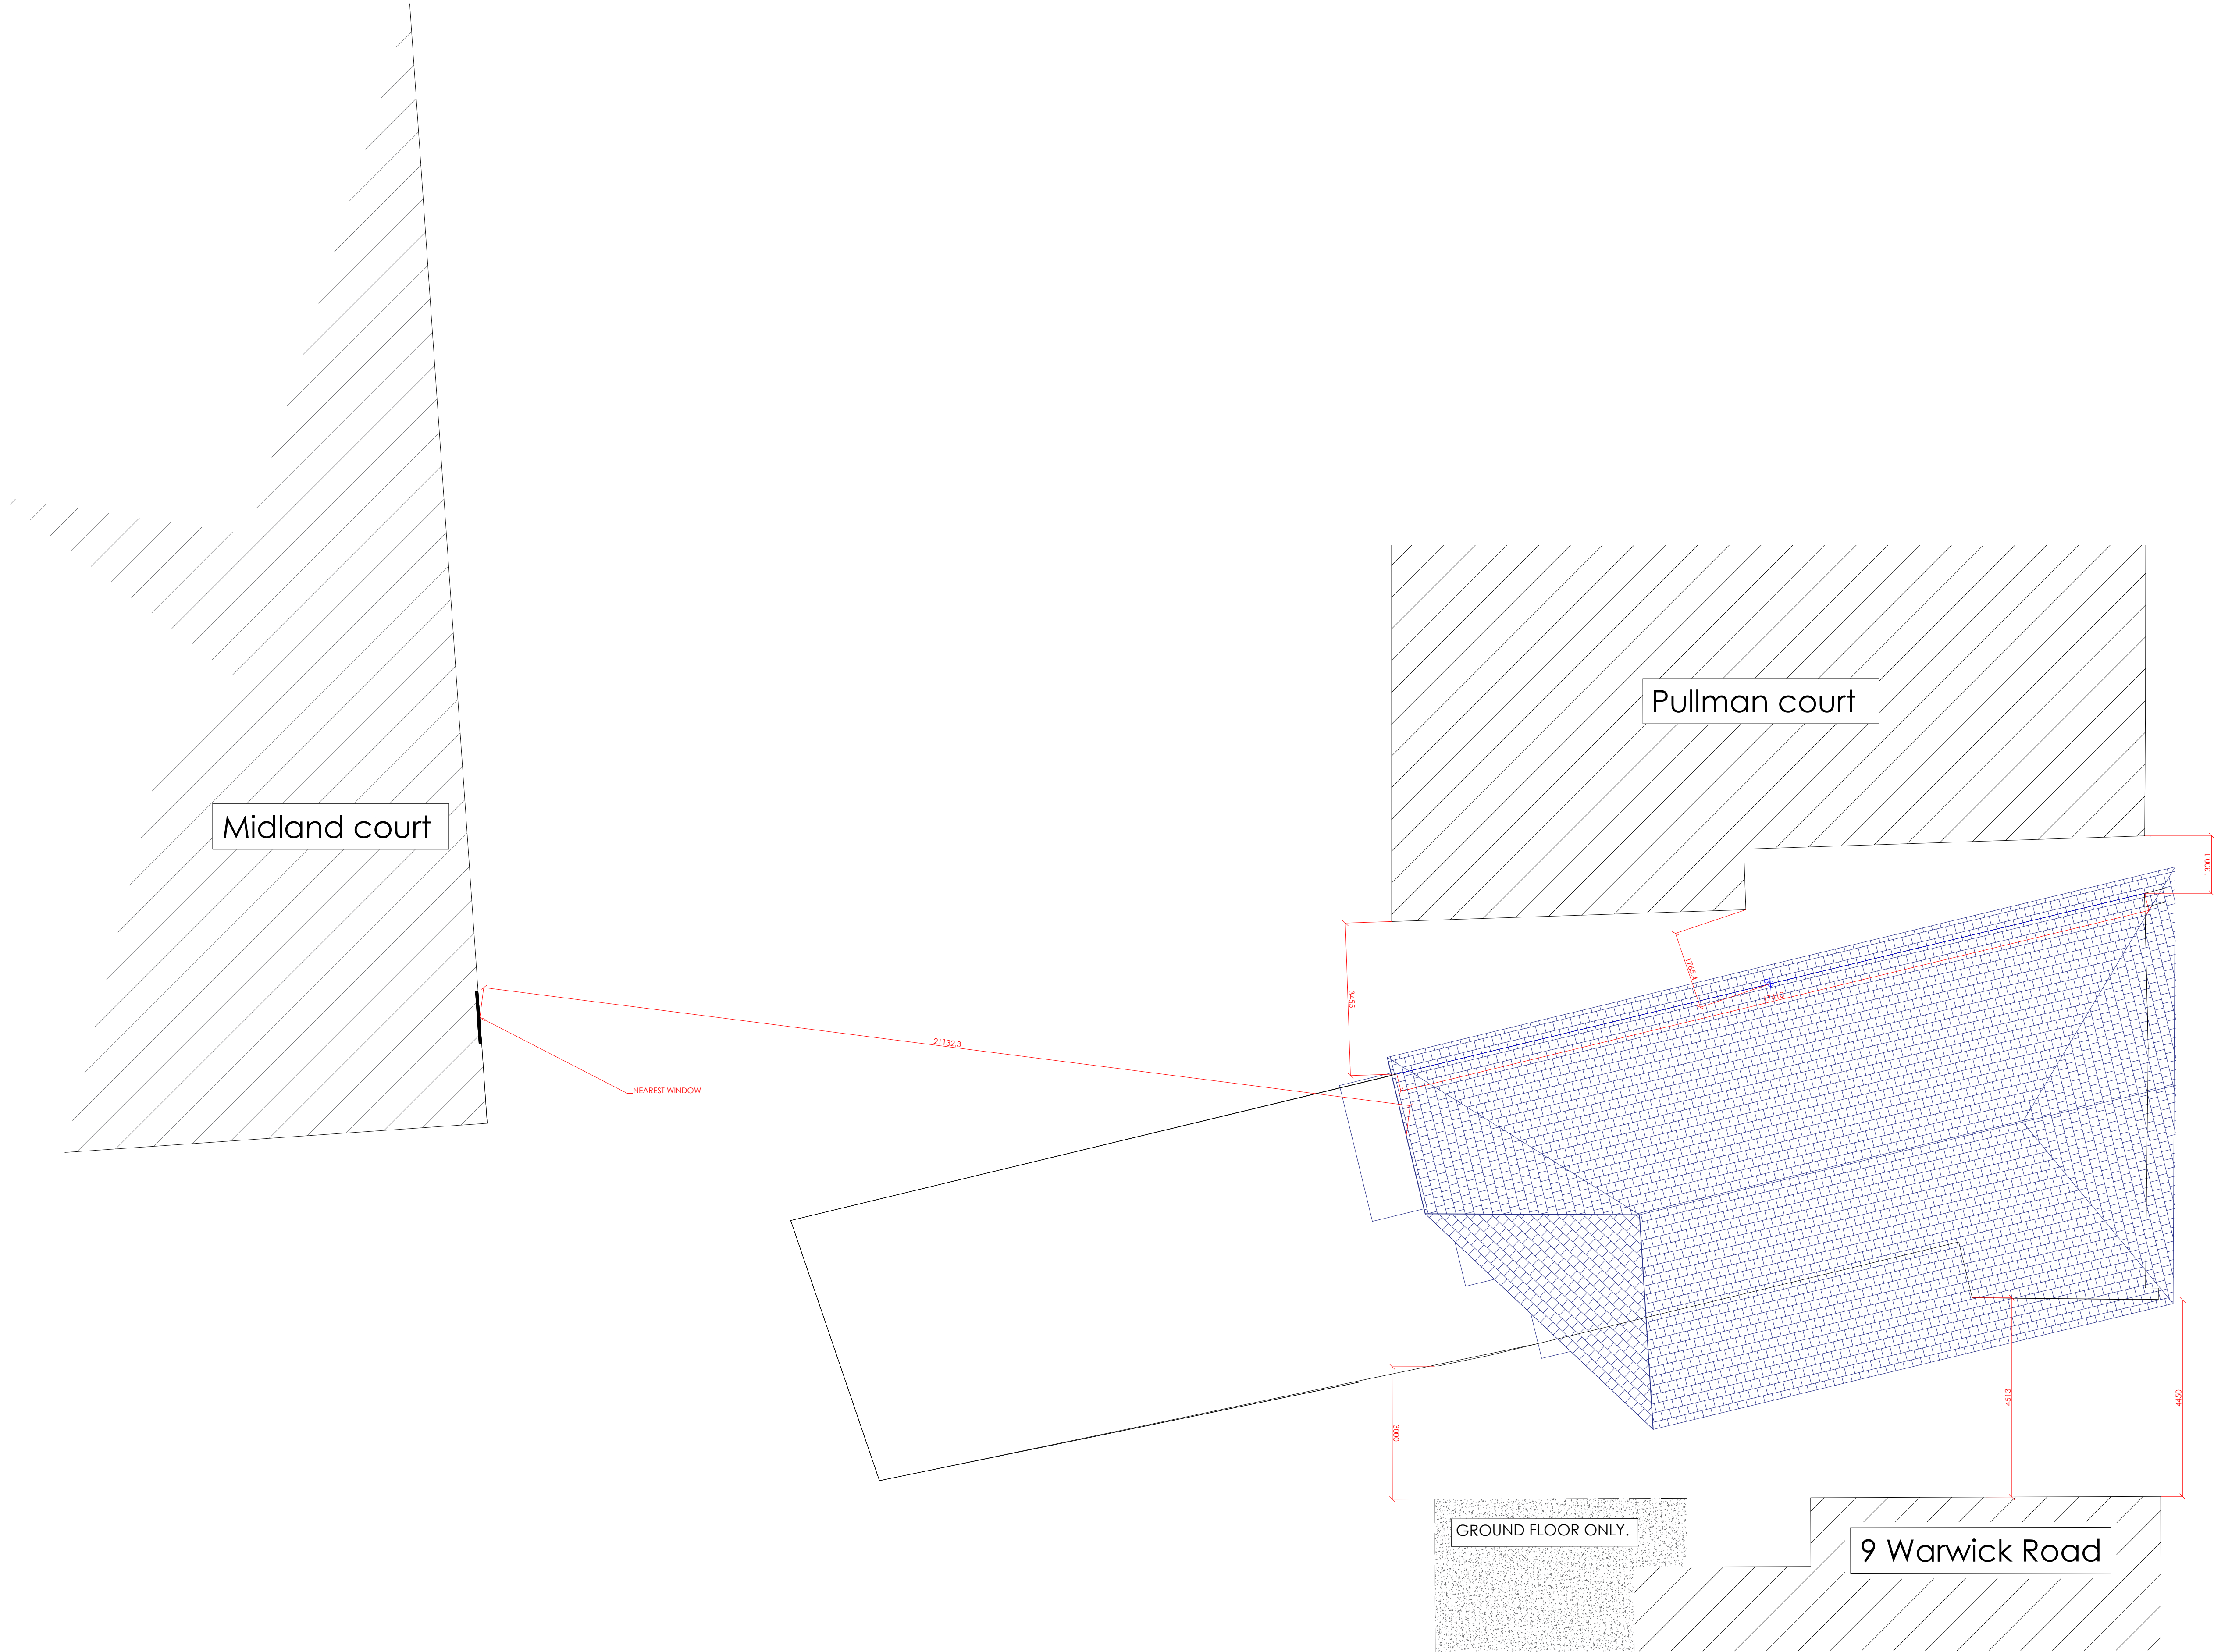

Legend

Client: SOUTHBOURNE ELECTRICAL

Southbourne 

SOUTHBOURNE ELECTRICAL SERVICES LIMITED
11, WARWICK ROAD, WEST DRAYTON
MIDDLESEX UB7 9BT
TEL: 01895 847417
CAD DEPARTMENT: JAMES@SOUTHBOURNE-ELECTRICAL.CO.UK

Project: 000
11 WARWICK ROAD
WEST DRAYTON

Title: SITE PLAN

Drawn by: JR		Checked by: JF	
Scale: 1:75@A1	Revision: -	Date: 20.04.21	

Drawing no.: SES-000-1-SP