


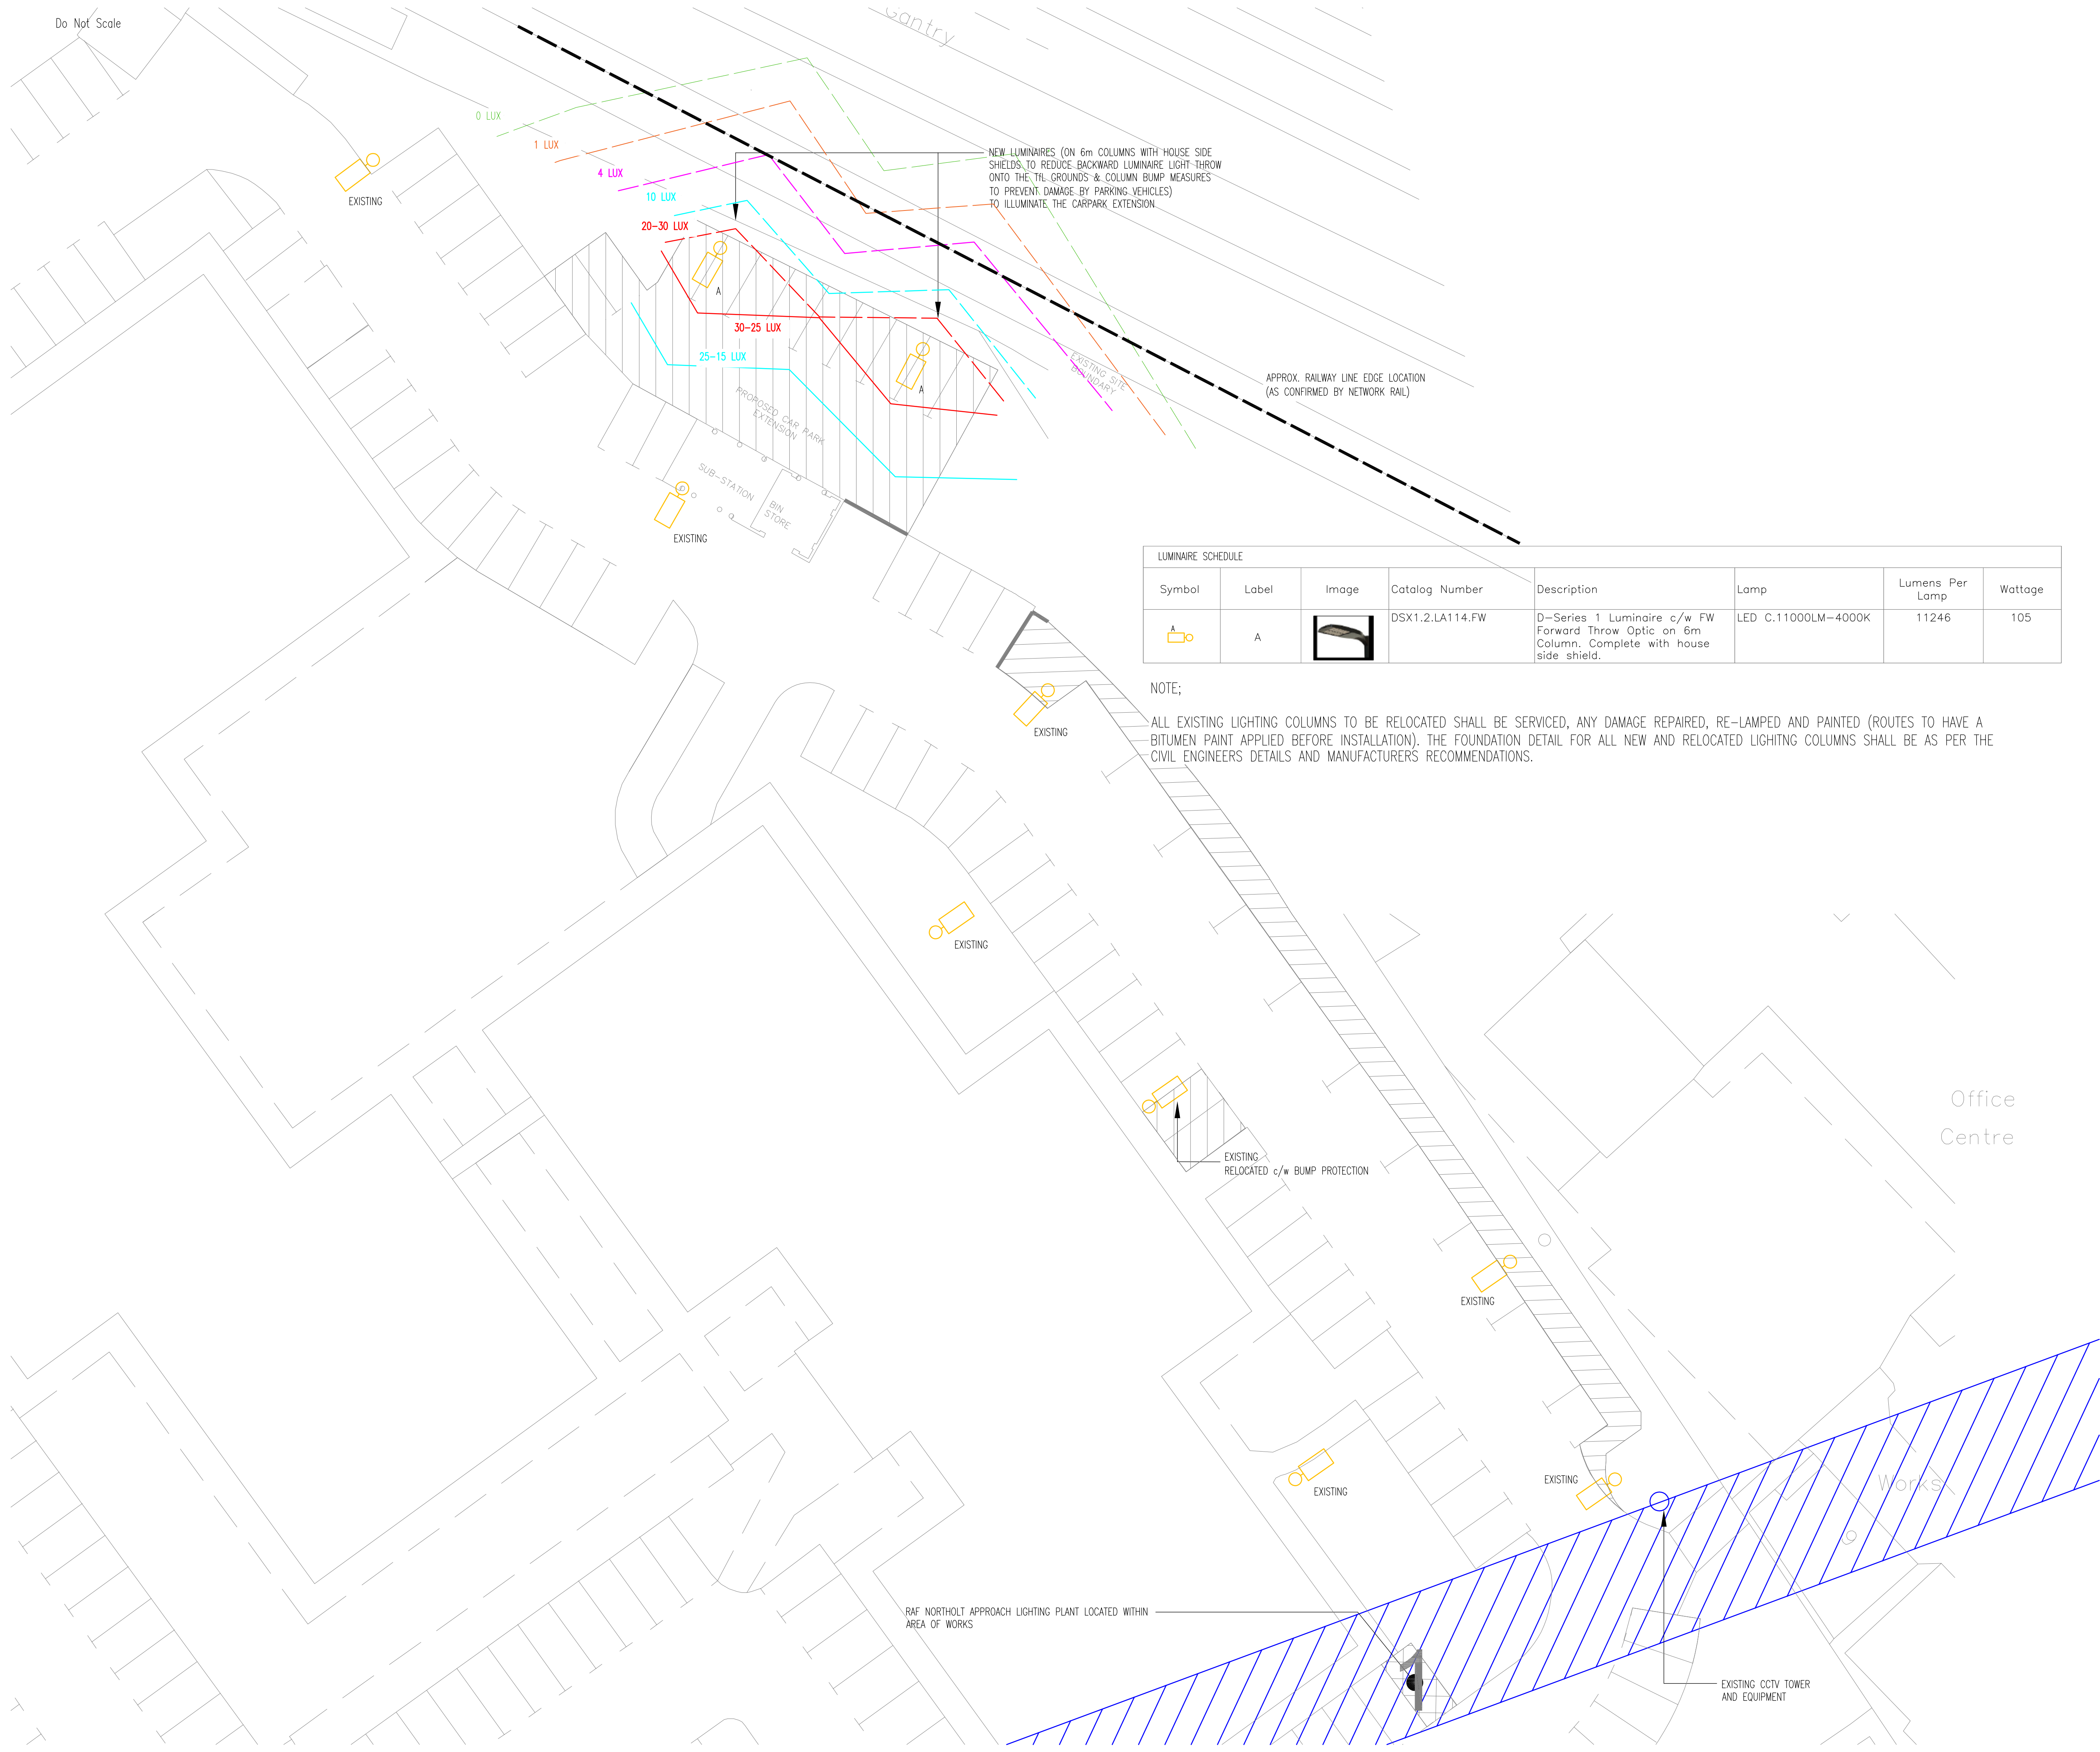

NOTES

1. READ THIS DRAWING IN CONJUNCTION WITH THE LANDSCAPE ARCHITECTS INFORMATION.

LUMINAIRE SCHEDULE							
Symbol	Label	Image	Catalog Number	Description	Lamp	Lumens Per Lamp	Wattage
	A		DSX1.2.LA114.FW	D-Series 1 Luminaire c/w FW Forward Throw Optic on 6m Column, Complete with house side shield.	LED C.11000LM-4000K	11246	105

NOTE;

ALL EXISTING LIGHTING COLUMNS TO BE RELOCATED SHALL BE SERVICED, ANY DAMAGE REPAIRED, RE-LAMPED AND PAINTED (ROUTES TO HAVE A BITUMEN PAINT APPLIED BEFORE INSTALLATION). THE FOUNDATION DETAIL FOR ALL NEW AND RELOCATED LIGHTING COLUMNS SHALL BE AS PER THE CIVIL ENGINEERS DETAILS AND MANUFACTURERS RECOMMENDATIONS.

P4	UPDATED TO INCLUDE DETAIL ON NEW LUMINAIRE SHIELDS	16/07/19	SK	JDB
P3	UPDATED TO INCLUDE LUX PLOT	01/07/19	SK	JDB
P2	UPDATED FOLLOWING COMMENTS	07/06/19	SK	JDB
P1	PLANNING ISSUE	29/04/19	SK	JDB

Rev	Description	Date	Eng	Check
-----	-------------	------	-----	-------

Issue Status

FOR PLANNING

Client

LASALLE INVESTMENT MANAGEMENT

MRB
Unit 1 Waterside
Old Boston Road
Wetherby
LS22 5NB
Tel: 01937 585082
email: office@mrbrb.uk.net

Project

ODYSSEY BUSINESS PARK MODIFICATIONS
SOUTH RUISLIP

Title
MECHANICAL AND ELECTRICAL SERVICES
EXTERNAL SERVICES

Drawn	Date	Scale
SK	APRIL'19	NTS@A1
Job No	Dwg No	Rev
W779	EX005	P4